




McDonald's


#44655 - 707 1/2 METROPOLITAN AVE - LEAVENWORTH, KS 66048

SIGN PROGRAM BOOK

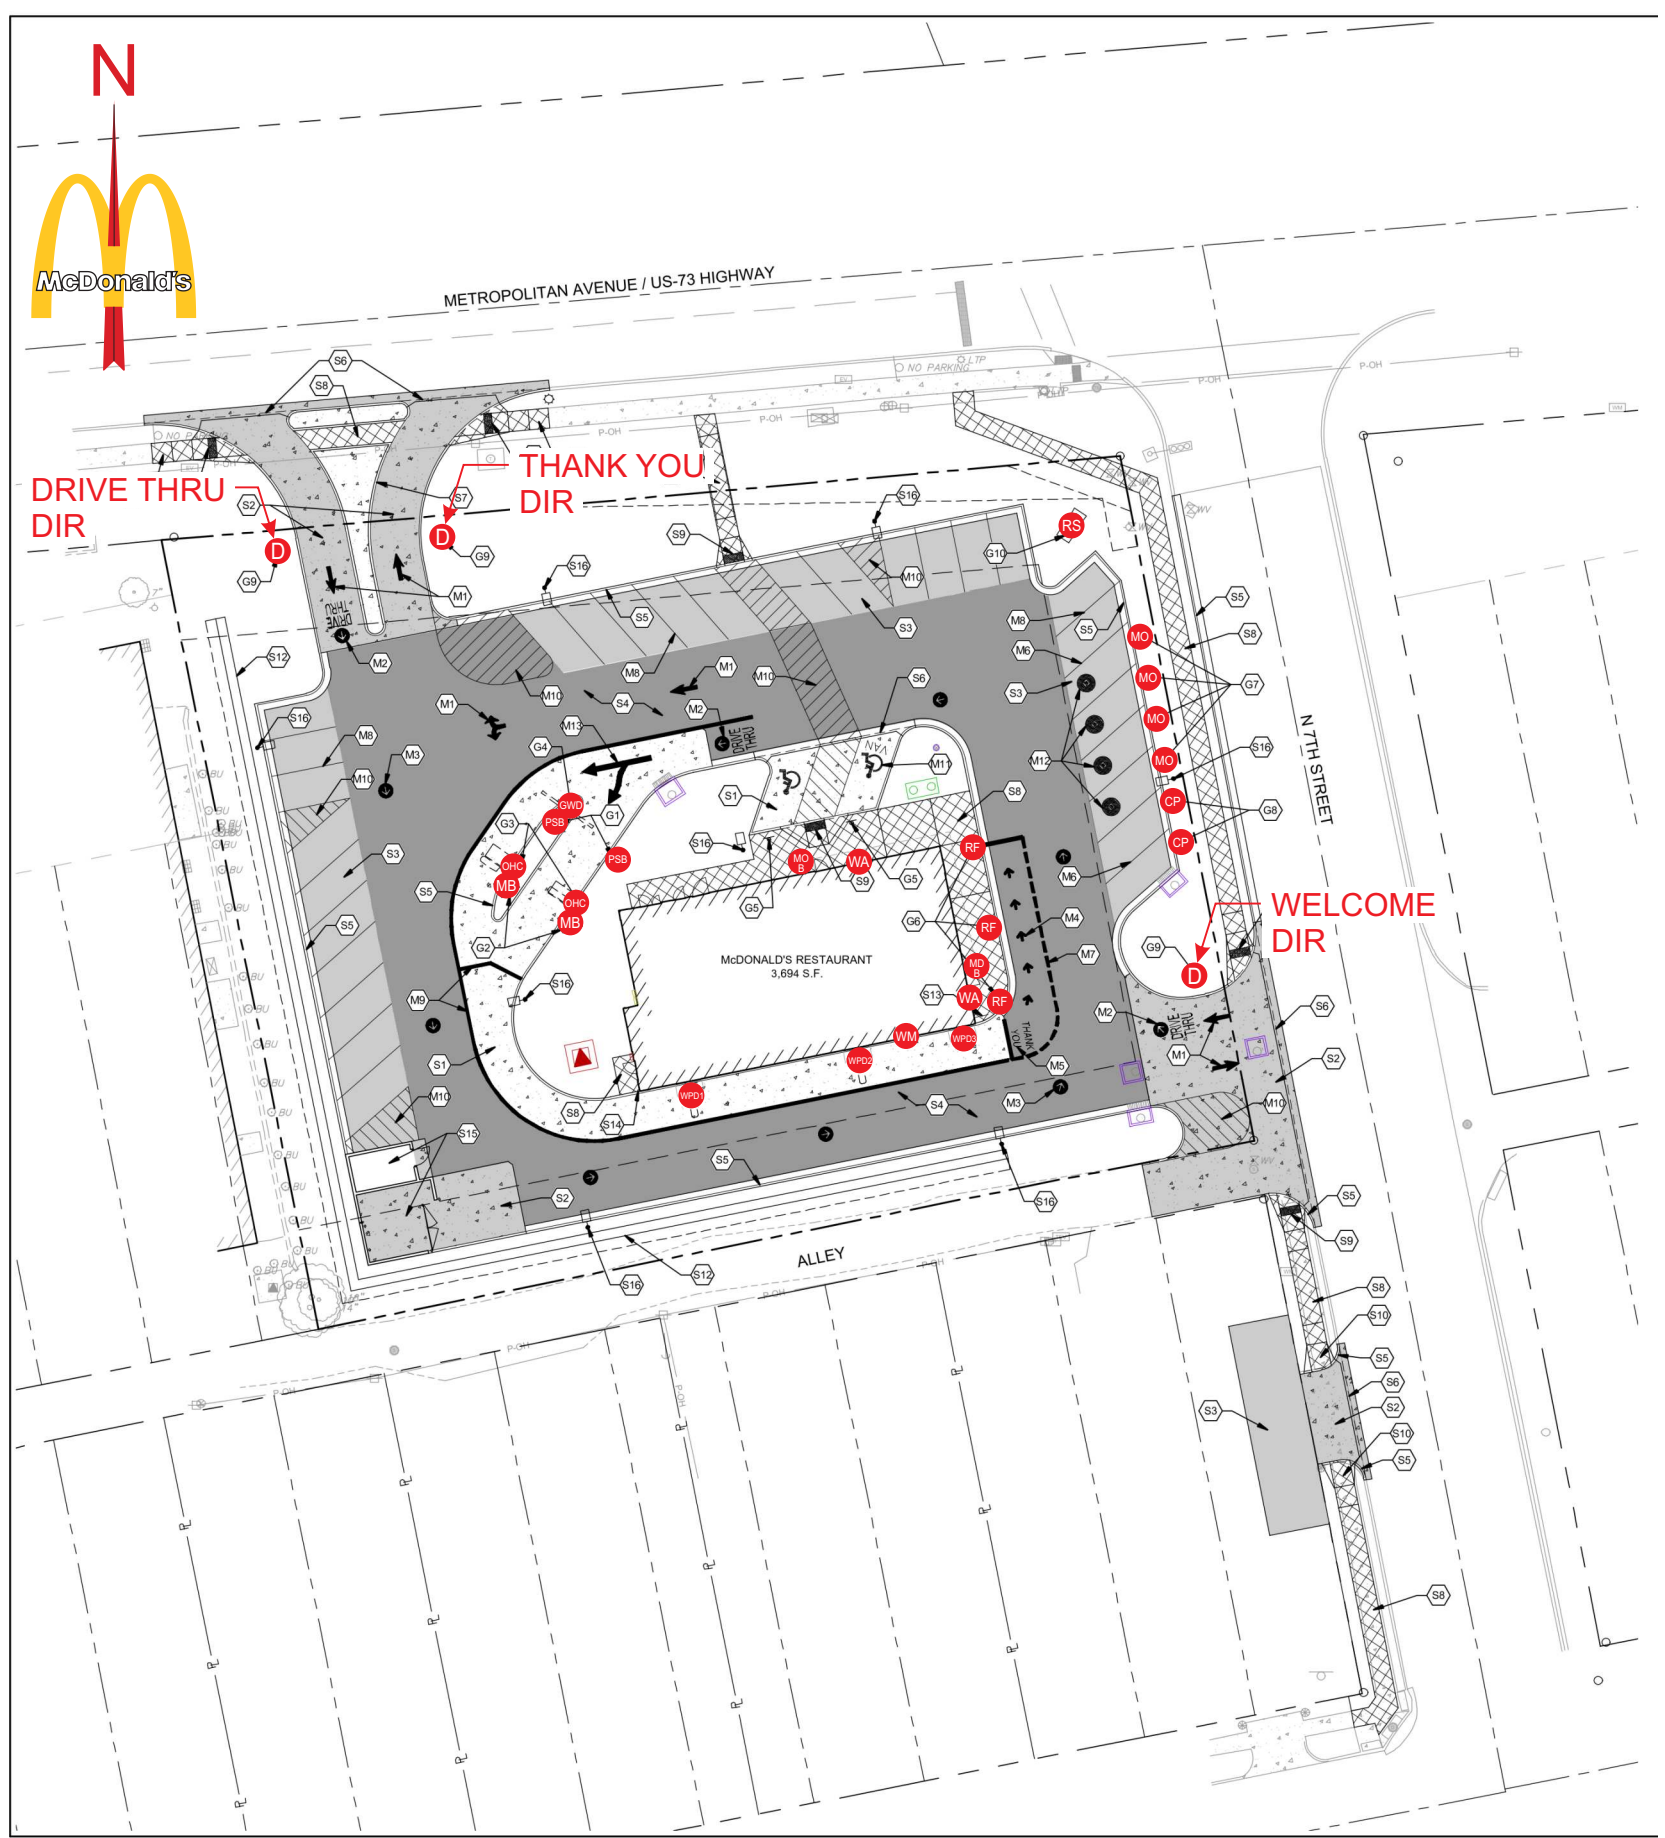


- MB MENU BOARD (QTY 2)
- OHC ORDER HERE CANOPY (QTY 2)
- PSB PRE-SELL BOARD (QTY 2)
- GWD DOUBLE ARM GATEWAY
- WPD1 WINDOW POSITION DECAL 1
- WPD2 WINDOW POSITION DECAL 2
- WPD3 WINDOW POSITION DECAL 3
- MO MOBILE ORDER SIGN (QTY 4)
- RF ROLL FORWARD SIGN (QTY 3)
- CP COURIER PARKING SIGN (QTY 2)
- WA WALL ARCH (QTY 2)
- WM 24" WORDMARK (QTY 1)
- MO_B MOBILE ORDER BLADE SIGN
- MD_B MCDELIVERY BLADE SIGN
- D DIRECTIONAL (QTY 3)
- RS ROAD SIGN


FRONT ELEVATION
SCALE: 3/16" = 1'-0"

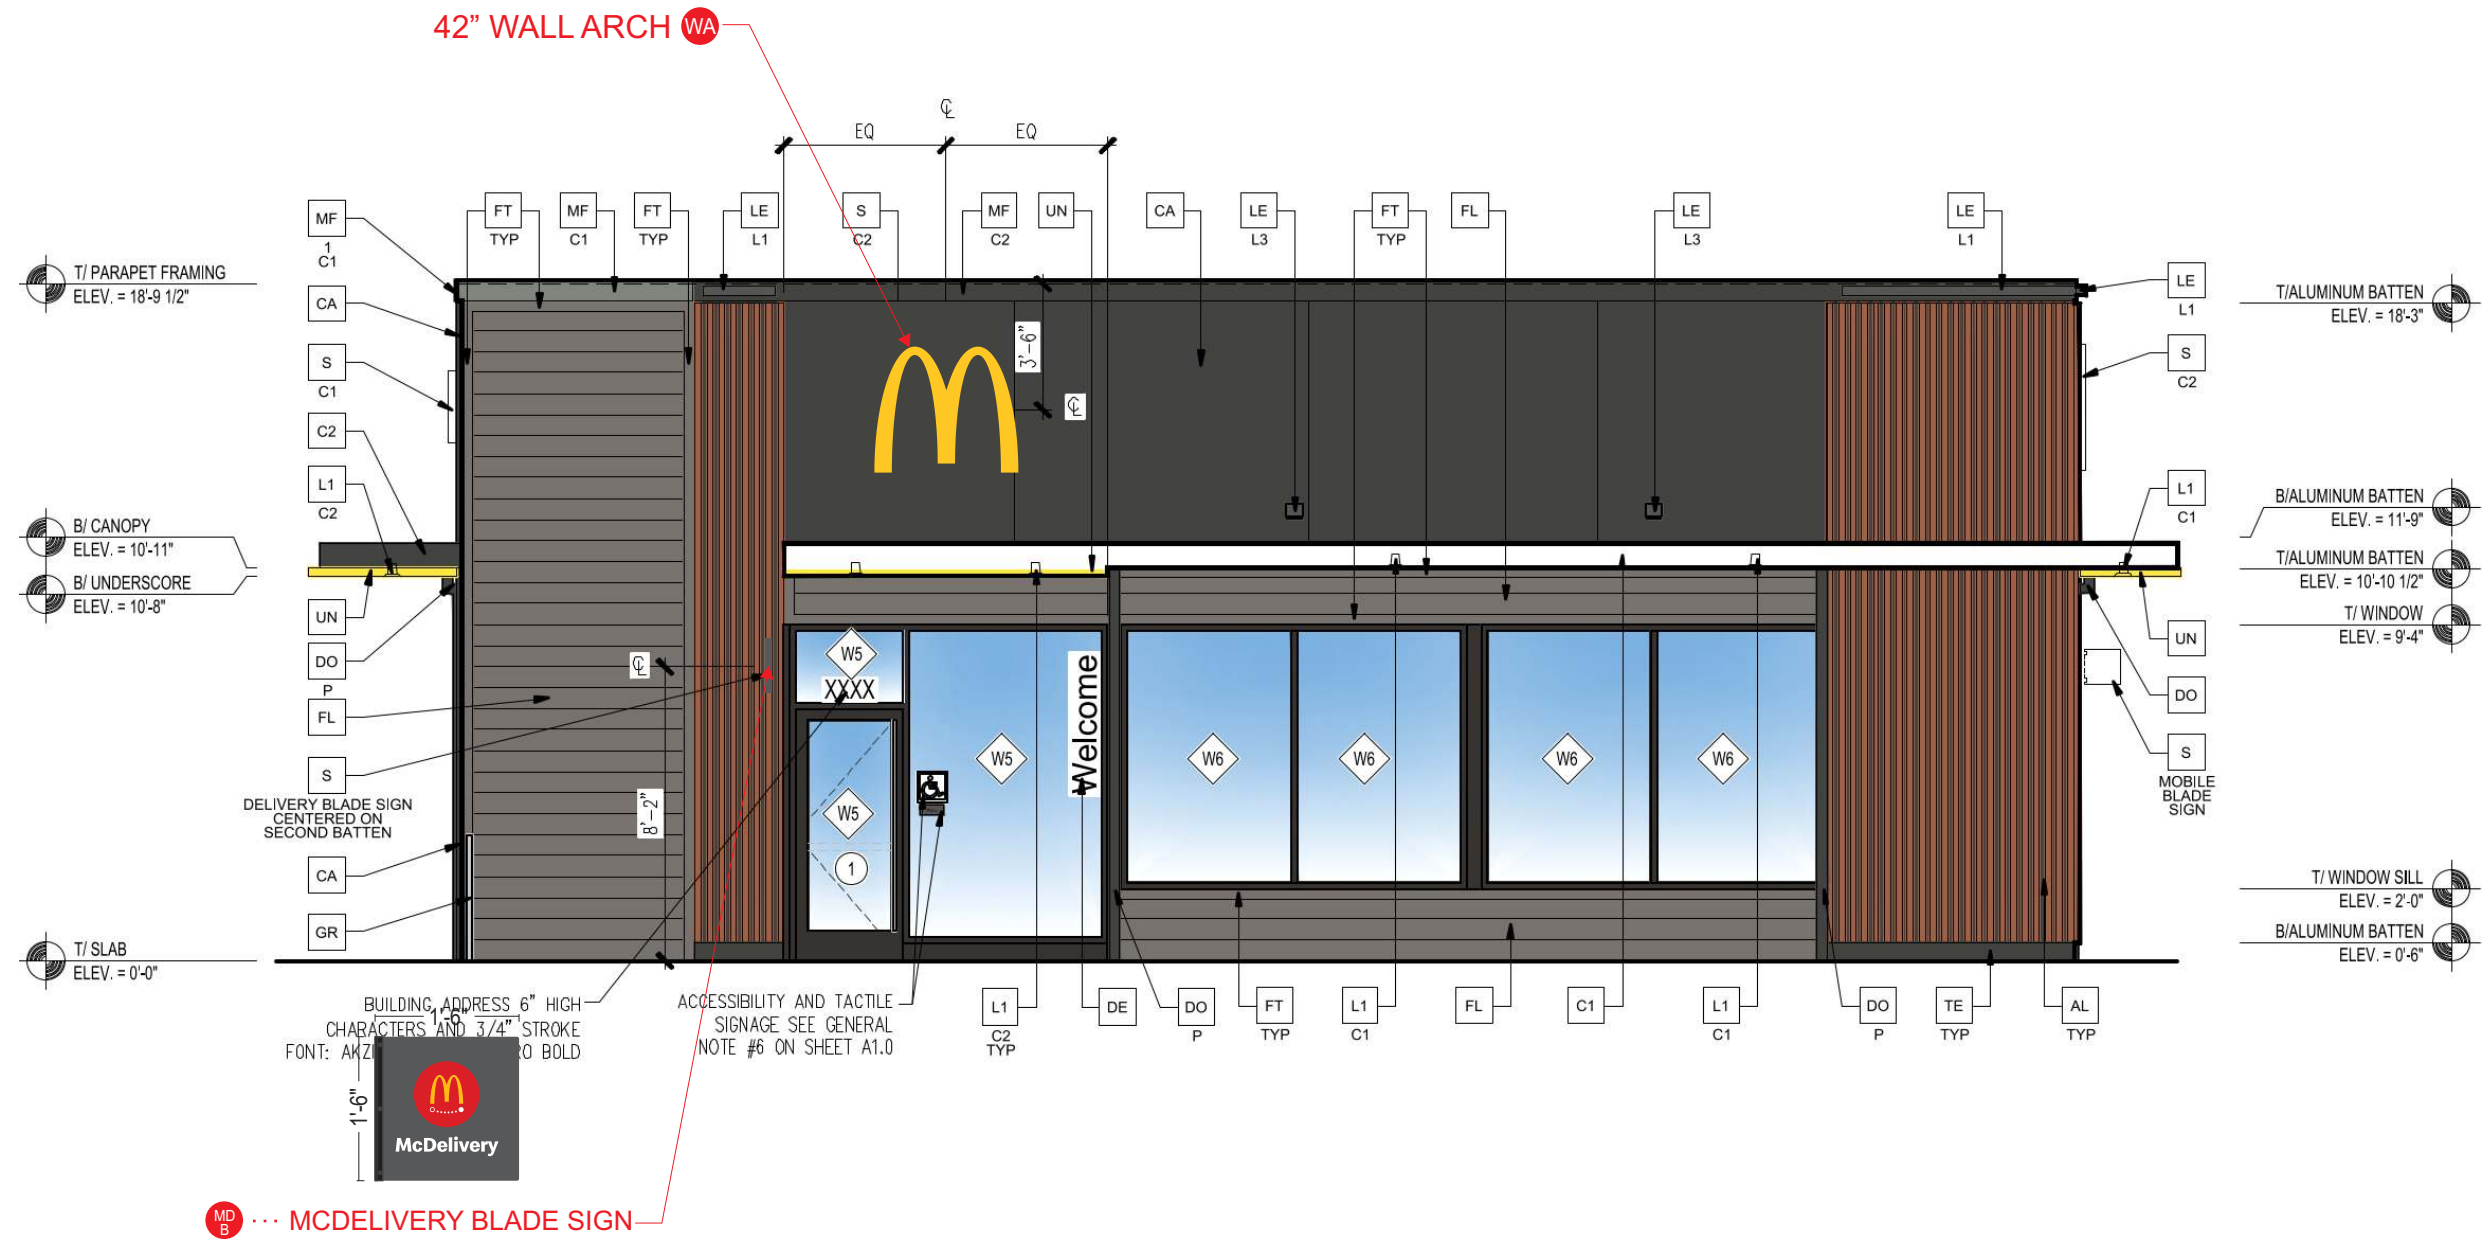

REAR ELEVATION
SCALE: 3/16" = 1'-0"

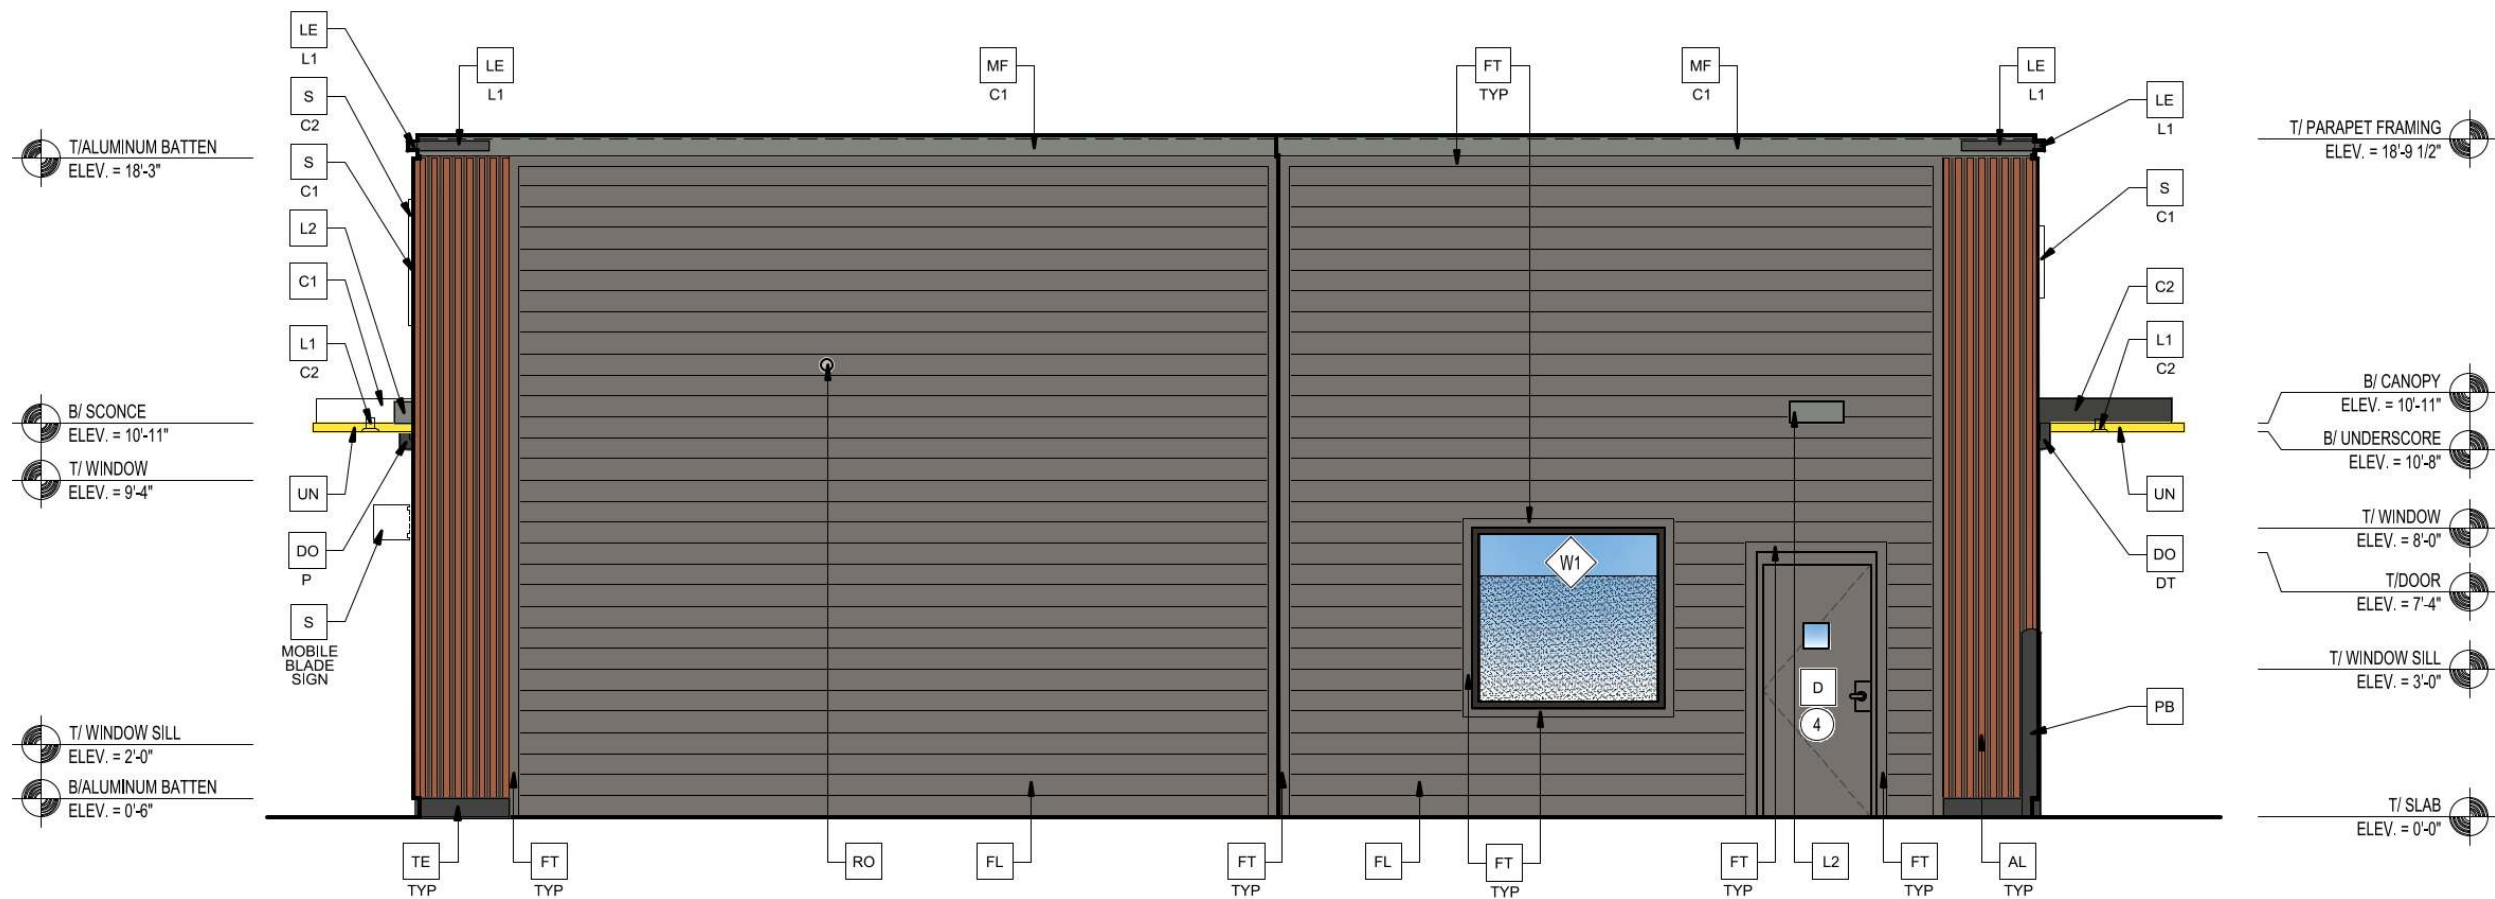

DRIVE-THRU ELEVATION
SCALE: 1/8" = 1'-0"

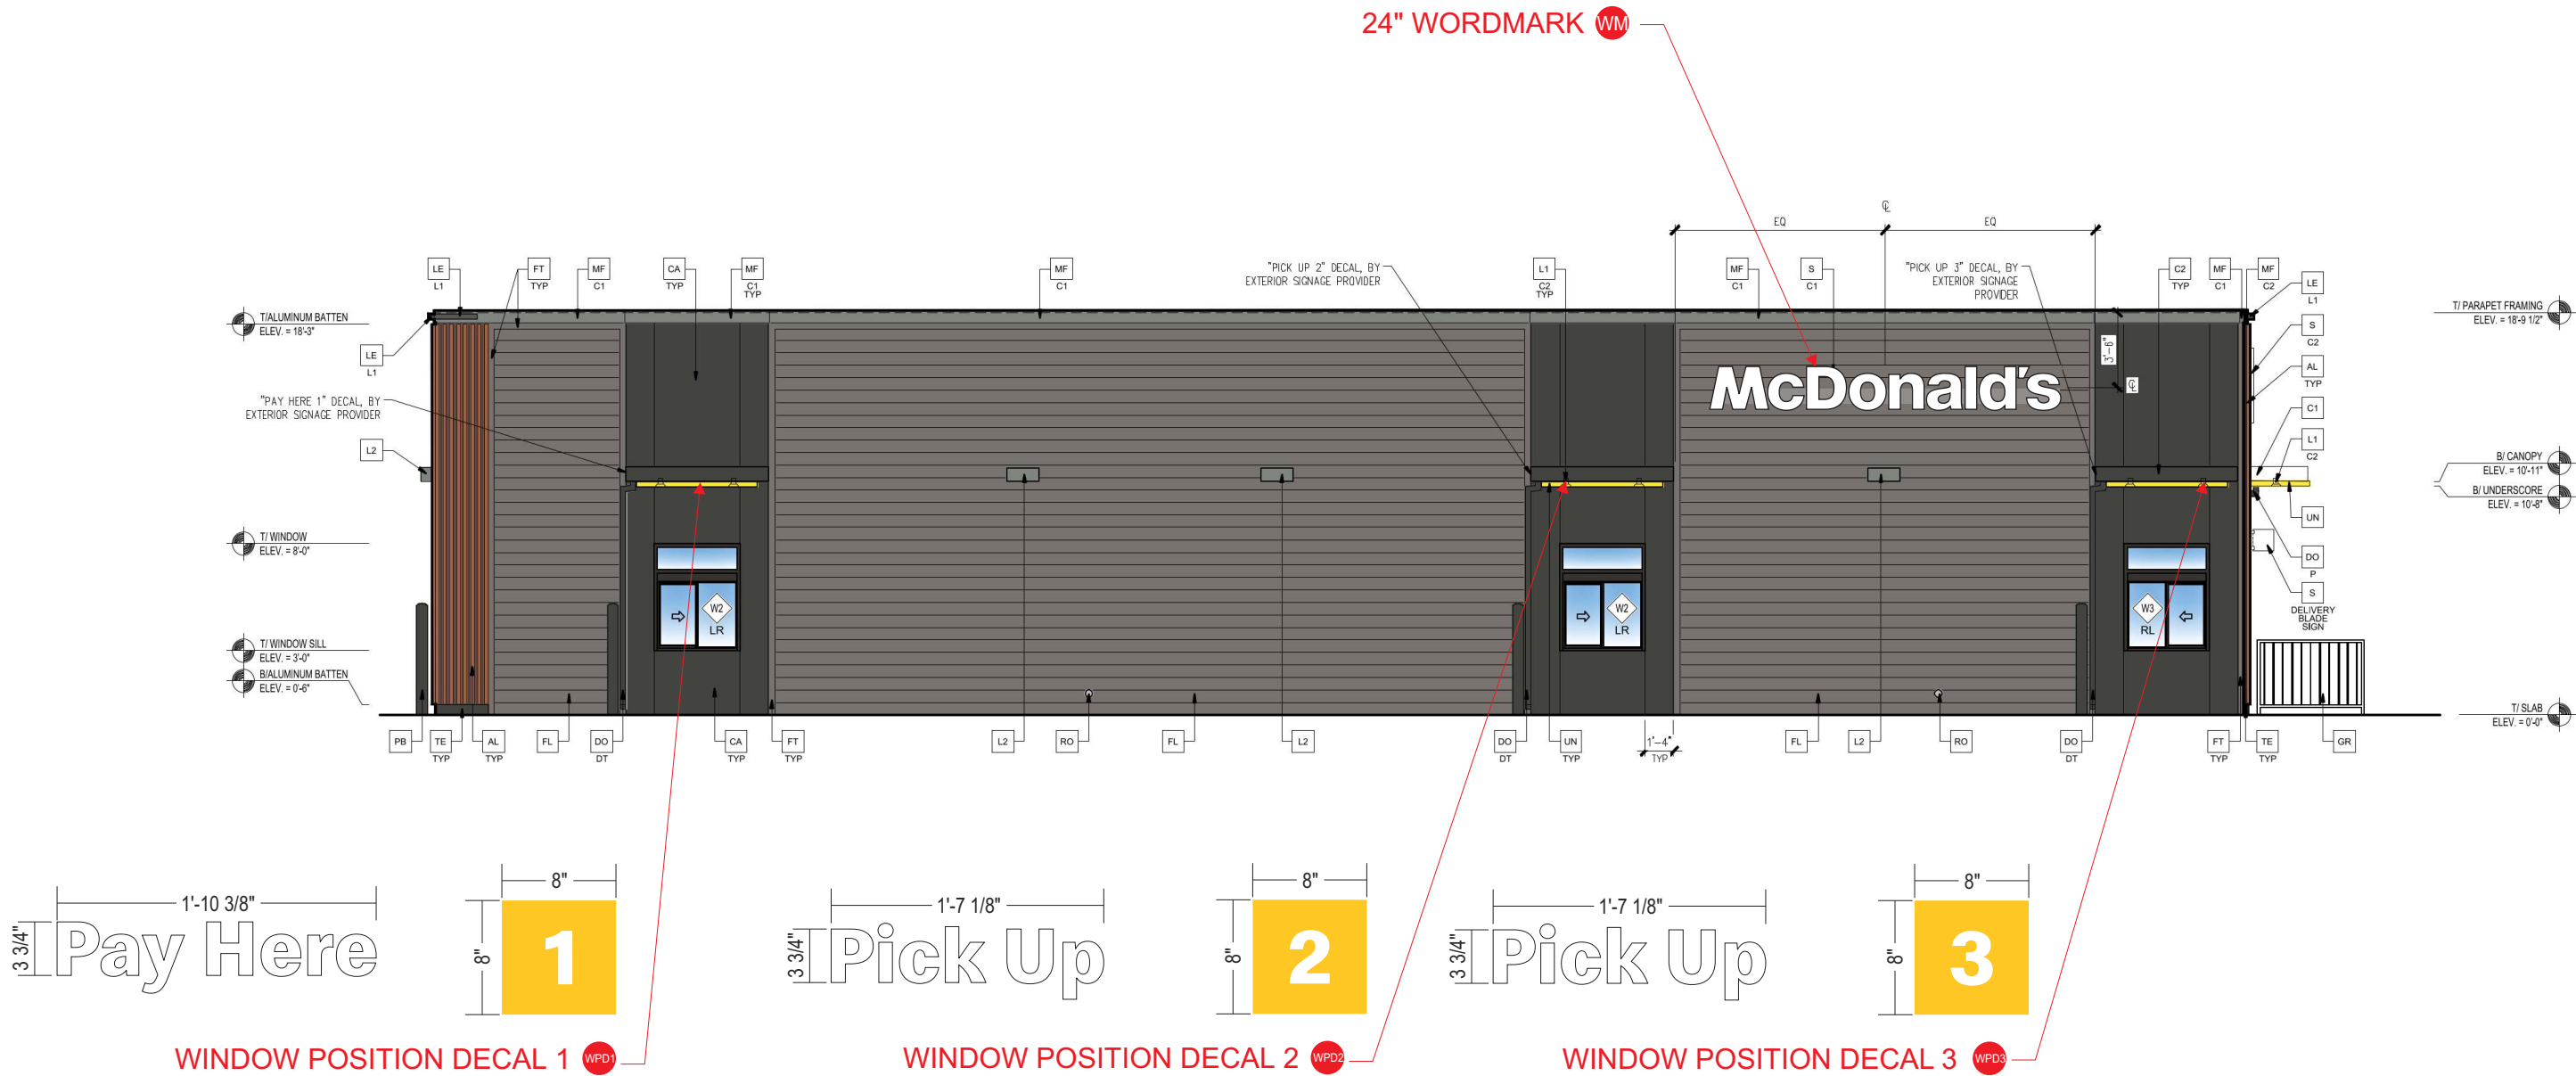


NON DRIVE-THRU ELEVATION
SCALE: 1/8" = 1'-0"



Frame	Hot dip galvanized + anti-graffiti powder coated steel
Brackets	Hot dip galvanized
Panels	Aluminium + anti-graffiti powdercoat
Access fasteners	Security Torx
Media player access	Dual camlock
Eyebolt	Stainless crane on
Baseplate	McDonalds spec triple mounting pattern option

ODMB 02 SINGLE	
Displays	Samsung OH55F
Hardware	Stratacache Spectra NG
Heating/Cooling	Watlow 100W Heater Sunon 120mm AC Fan
Power Supply Units	60W DC Media Player Power Supply
Power Cables	1 x IEC Power Cable
Electrical Components	Isolated Ground 2 x IG Receptacles 20A Circuit Breaker
Communication Cables	2 x HDMI 1 x RS232
Certification	UL Certified

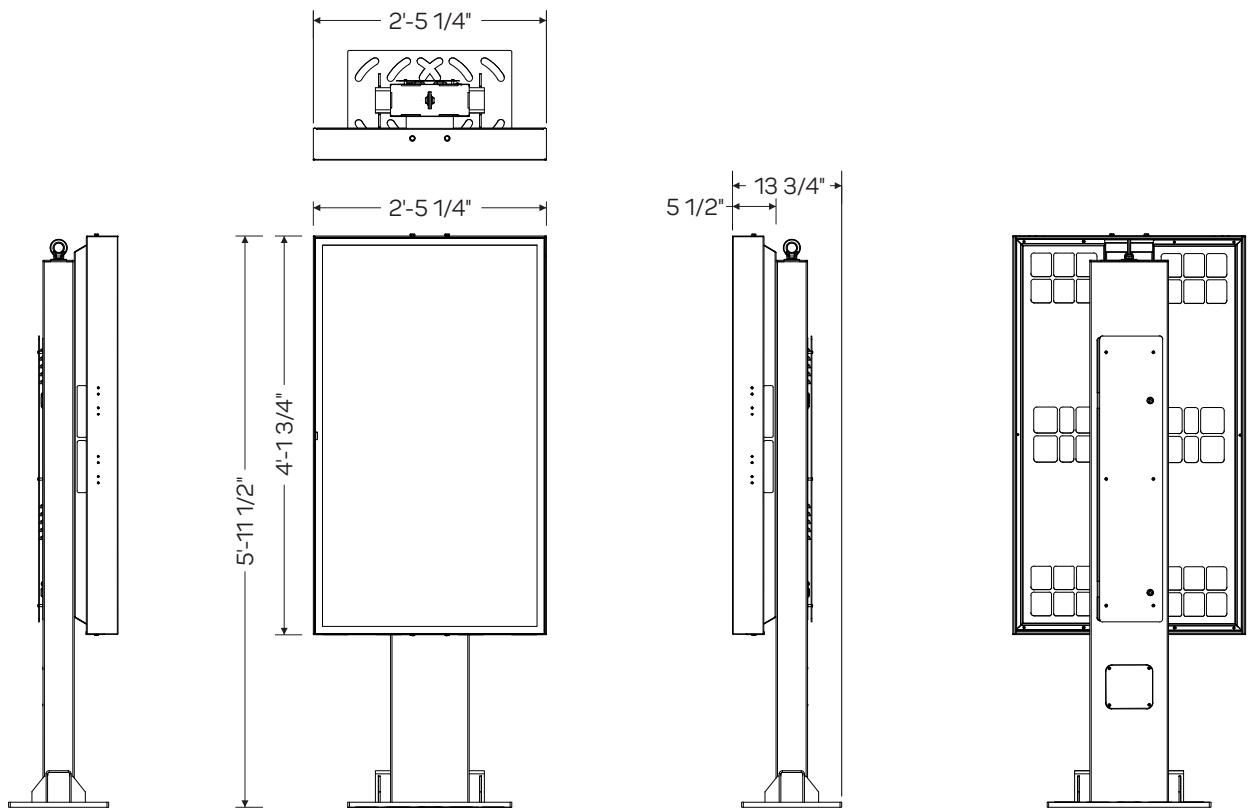

SCALE: 1/2" = 1'-0"




GRAPHIC DETAIL
NOT TO SCALE



Frame	Hot dip galvanized + anti-graffiti powder coated steel
Brackets	Hot dip galvanized
Panels	Aluminium + anti-graffiti powdercoat
Access fasteners	Security Torx
Media player access	Dual camlock
Eyebolt	Stainless crane on
Baseplate	McDonalds spec triple mounting pattern option

ODMB 02 DOUBLE

Displays	2 x Samsung OH55F
Hardware	2 x Stratacache Spectra NG
Heating/Cooling	Watlow 100W Heater Sunon 120mm AC Fan
Power Supply Units	2 x 60W DC Media Player Power Supply
Power Cables	2 x IEC Power Cables
Electrical Components	Isolated Ground 2 x IG Receptacles 20A Circuit Breaker
Communication Cables	4 x HDMI 2 x RS232
Certification	UL Certified

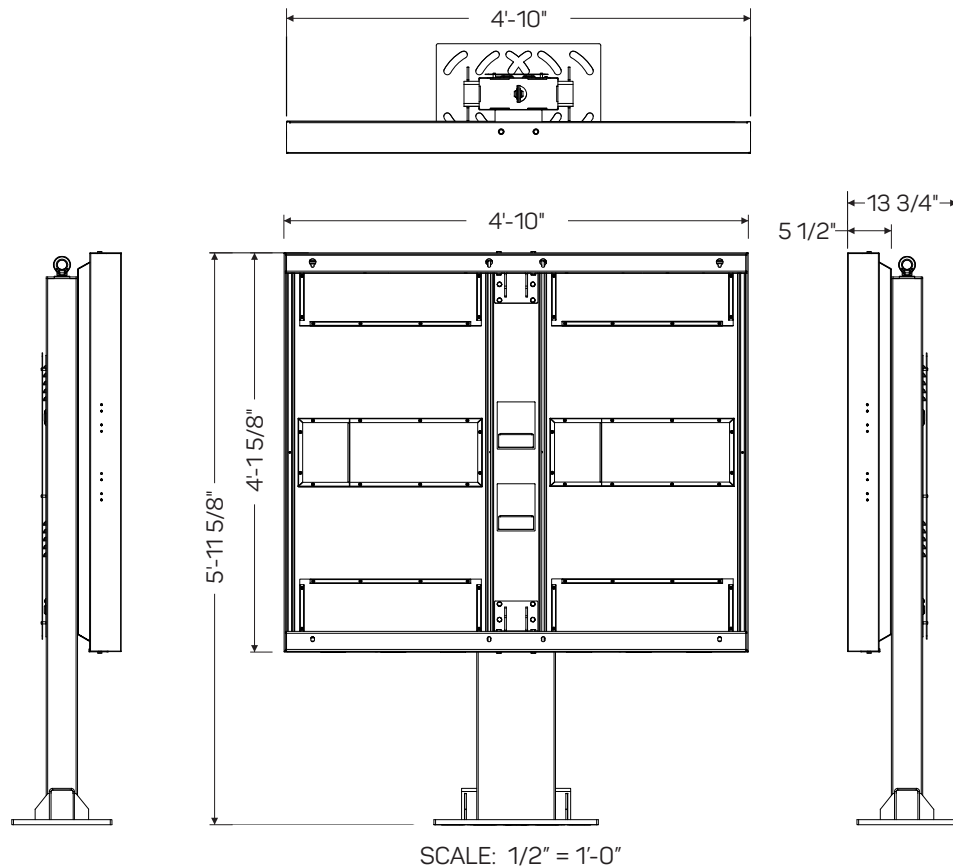

SCALE: 1/2" = 1'-0"

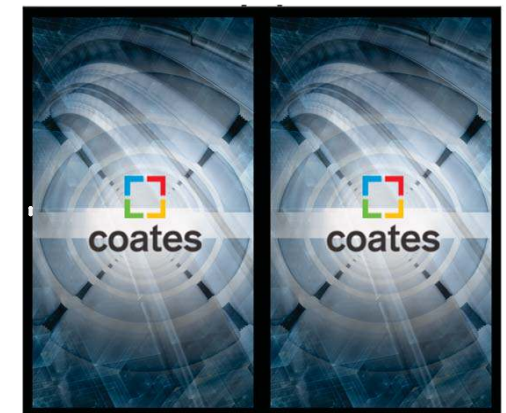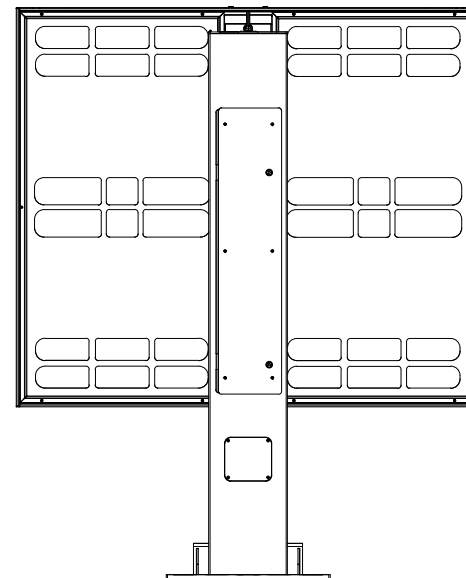




GRAPHIC DETAIL
NOT TO SCALE



This sign is intended to be installed in accordance with the requirements of Article 600 of the National Electric Code and/or other applicable local codes. This includes proper grounding and bonding of the sign.

This is an original document created by Persona Signs, LLC provided specifically to the client for the client's personal use. This document should not be shared, reproduced, disclosed or otherwise used without written permission from Persona Signs, LLC.

Pay Here
Pick Up

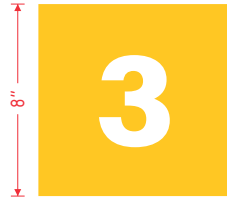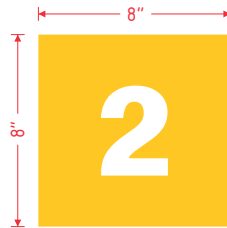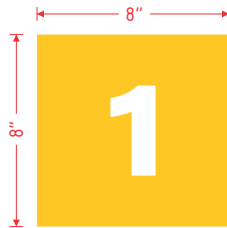

GRAPHIC DETAILS
SCALE: 1 1/2" = 1'-0"

SPECIFICATIONS

- 3M 7725-20 MATTE WHITE OPAQUE FILM
- 3M 7725-25 SUNFLOWER OPAQUE FILM
- FONT = SPEEDEE BOLD



TRELLIS POSITIONING DETAIL
SCALE: 1 1/2" = 1'-0"



This sign is intended to be installed in accordance with the requirements of Article 600 of the National Electric Code and/or other applicable local codes. This includes proper grounding and bonding of the sign.


This is an original document created by Persona Signs, LLC provided specifically to the client for the client's personal use. This document should not be shared, reproduced, disclosed or otherwise used without written permission from Persona Signs, LLC.

Customer Approval (Please Initial):

Approval Date:




GRAPHIC DETAIL
SCALE: 3" = 1'-0"

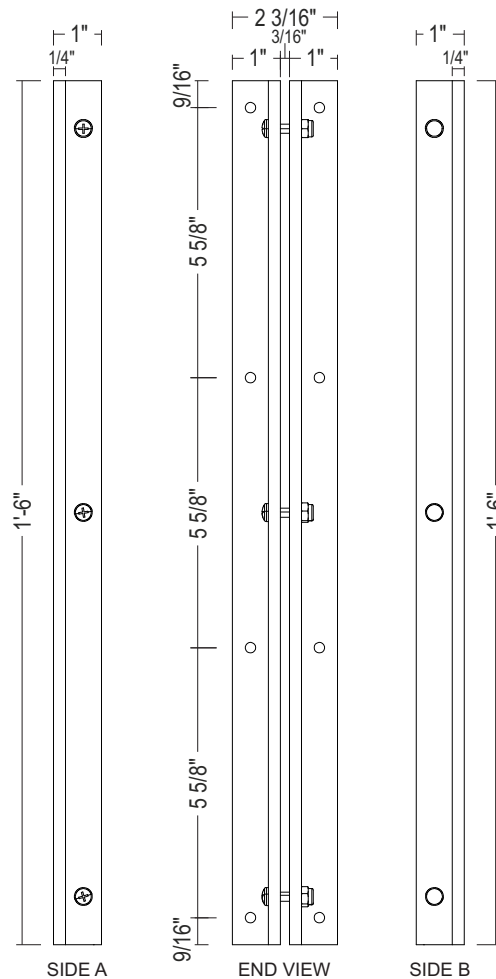

MOUNTING BRACKET DETAIL
SCALE: 3" = 1'-0"

SPECIFICATIONS:

- MOUNTING BRACKET:
(2) 1" X 1" X 1/4" X 18" ALUMINUM ANGLES;
POWDER COATED BLACK
- FACE ATTACHMENT: 10-24 X .75" THREAD-
CUTTING SCREWS WITH NYLOCK NUTS,
POWDER COATED BLACK
- .187" ALUMINUM FACE, POWDER COATED TO
MATCH NG CHARCOAL
- DECORATION (BOTH SIDES):
3M 3630-33 RED FILM
3M 7725-25 YELLOW FILM
- BOXED SIGN AREA: 2.25 SQ FT

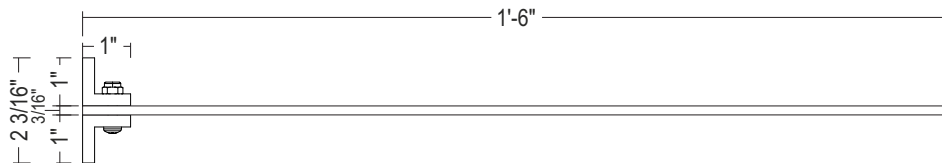

PLAN VIEW
SCALE: 3" = 1'-0"



PERSONA TRIANGLE
FACILITY SERVICES | LIGHTING | SIGNAGE

700 21st St SW
Watertown, SD 57201
Tel: 800.843.9888
www.personatriangle.com

Customer:
McDONALD'S

Location:
LEAVENWORTH, KS

File Name:
532521 - 707 1/2 METROPOLITAN AVE - LEAVENWORTH, KS

Project No.:
532521

Prepared By:
CTM

Date:
04/02/26

Request No.:
88775

Revision:
1



This sign is intended to be installed in accordance with the requirements of Article 600 of the National Electric Code and/or other applicable local codes. This includes proper grounding and bonding of the sign.


This is an original document created by Persona Signs, LLC provided specifically to the client for the client's personal use. This document should not be shared, reproduced, disclosed or otherwise used without written permission from Persona Signs, LLC.

Customer Approval (Please Initial):

Approval Date:




GRAPHIC DETAIL
SCALE: 3" = 1'-0"

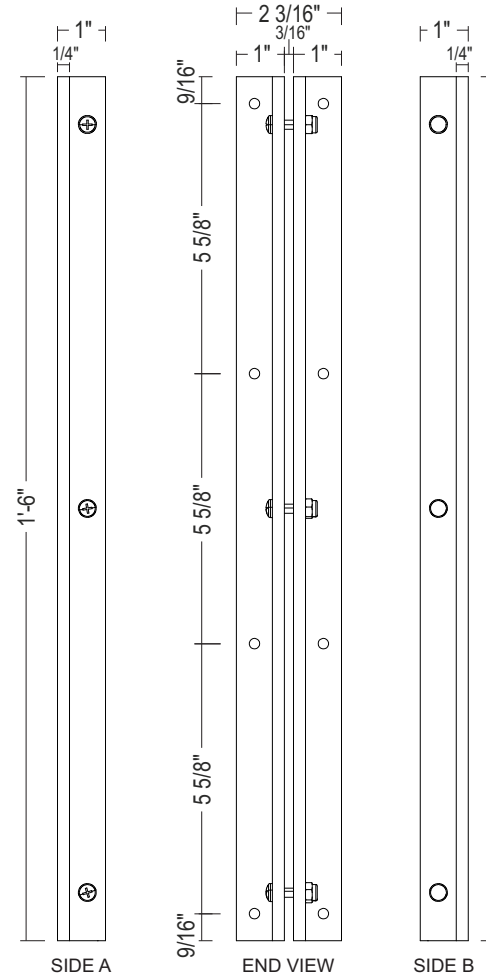


MOUNTING BRACKET DETAIL
SCALE: 3" = 1'-0"

- SPECIFICATIONS:**
- MOUNTING BRACKET:
(2) 1" X 1" X 1/4" X 18" ALUMINUM ANGLES;
POWDER COATED BLACK
 - FACE ATTACHMENT: 10-24 X .75" THREAD-
CUTTING SCREWS WITH NYLOCK NUTS,
POWDER COATED BLACK
 - .187" ALUMINUM FACE, POWDER COATED TO
MATCH NG CHARCOAL
 - DECORATION (BOTH SIDES):
3M 3630-33 RED FILM
3M 7725-25 YELLOW FILM
3M 7725-20 WHITE FILM
 - BOXED SIGN AREA: 2.25 SQ FT

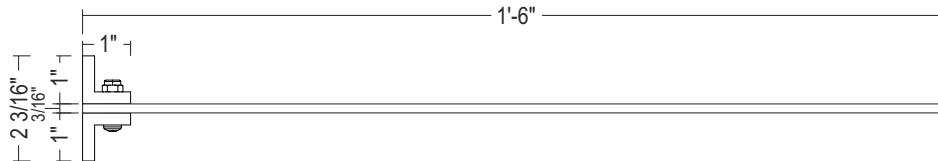

PLAN VIEW
SCALE: 3" = 1'-0"

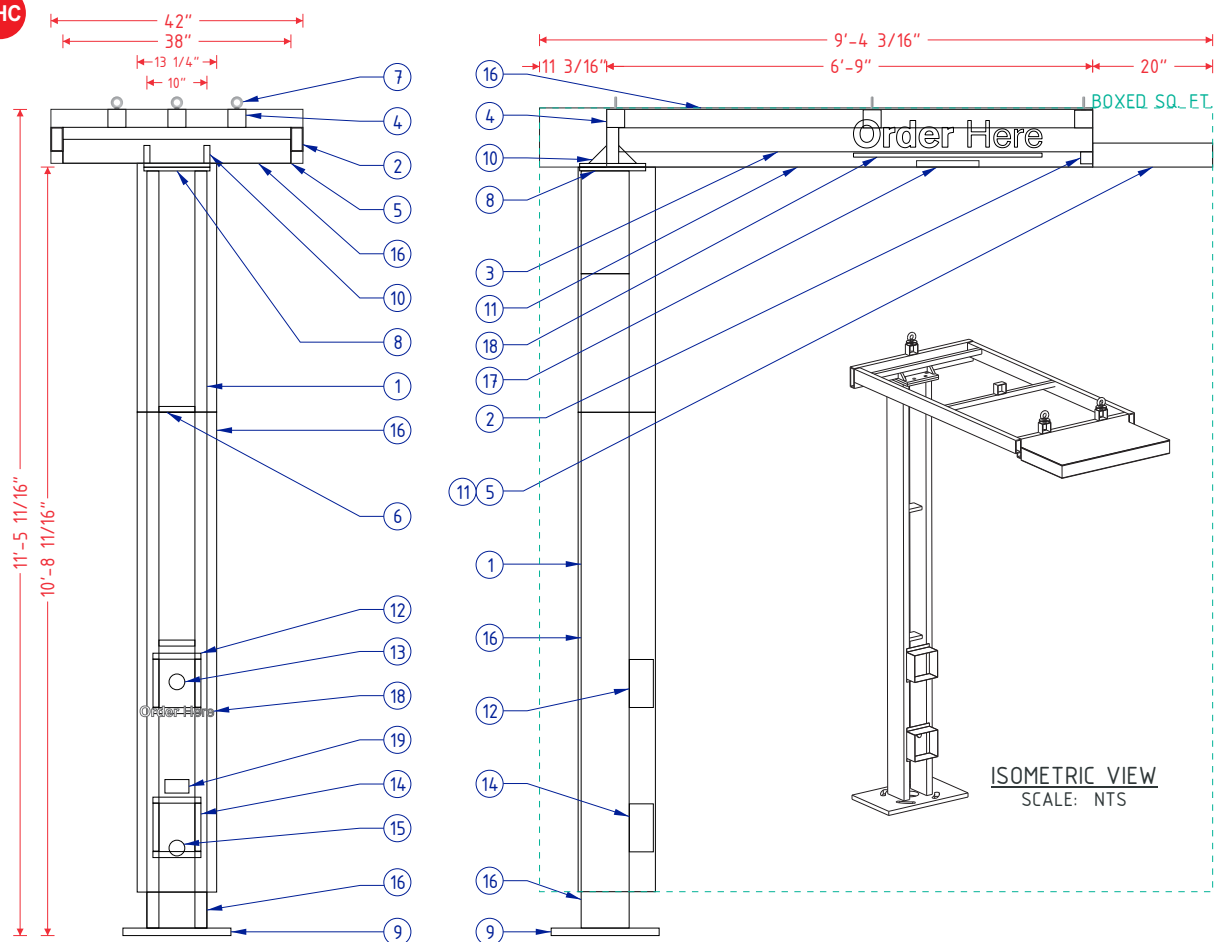

FRAME & LAMP DETAIL
SCALE: 3/8" = 1'-0"

18" X 18" X 1" PLATE
1 3/8" SLOTTED HOLES
1" BOLTS

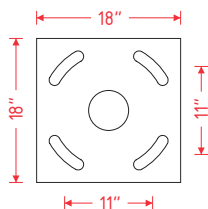


PLATE DETAIL
SCALE: 1/2" = 1'-0"

CROSS SECTION A-A
SCALE: 3/8" = 1'-0"

11" X 11" X 5/8" PLATE
3/4" HOLES
5/8" BOLTS


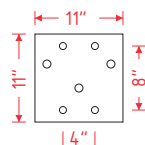


PLATE DETAIL
SCALE: 1/2" = 1'-0"


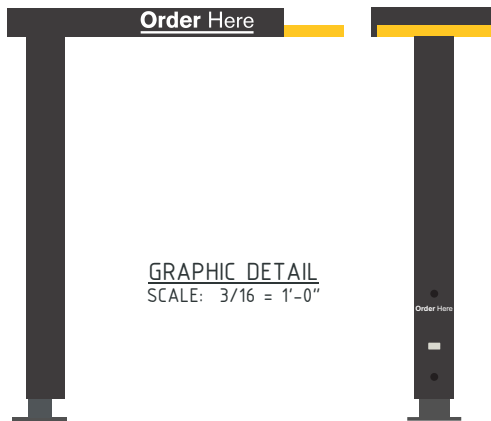


GRAPHIC DETAIL
SCALE: 3/16" = 1'-0"


MCDONALD'S SPRINGBOARD OHC SPECIFICATIONS	
NO.	PART/DESCRIPTION
1	2" X 6" X 3/16" RECTANGULAR TUBE
2	2" X 6" X 1/4" RECTANGULAR TUBE
3	2" X 4" X 1/4" RECTANGULAR TUBE
4	3" X 3" X 3/16" TUBE
5	1" X 4" C-CHANNEL
6	2" X 6" X 3/16" RECTANGULAR TUBE
7	1/2" EYEBOLTS (3)
8	11" X 11" X 5/8" TOP PLATES (2) (SEE PLATE DETAILS)
9	18" X 18" X 1" BASE PLATE (SEE PLATE DETAILS)
10	3" X 3" X 3/4" GUSSETS (2)
11	.063" SKIN
12	.063" ALUMINUM BENT SP10 SPEAKER BOX HOLDER
13	SPEAKER OPENING
14	.063" ALUMINUM BENT DM 4/DM 5 MICROPHONE BOX HOLDER
15	MICROPHONE OPENING
16	ACM CLADDING
17	3000K SLOAN LED LIGHT
18	3M 680-10 REFLECTIVE WHITE FILM 1ST SURFACE
19	ADA STICKER

NOTES:

- 2" X 6" X 3/16 RECTANGULAR TUBE FRAME
- ACM AND .063" ALUMINUM SKIN
- EXTERIOR FINISH:
 - BASE PLATE - PAINT BM 1631 MIDNIGHT OIL
 - TUBE AND TOP ACM - PAINT CHARCOAL
 - SPRINGBOARD TIP AND UNDERSIDE - PAINT PMS 123C
- ACM/SKIN REMOVABLE FOR SERVICE
- U.L. LISTED
- (1) 20A / 120V CIRCUIT REQUIRED
- SQUARE FOOTAGE:
 - BOXED AREA: 101.52 SQ. FT.
 - ACTUAL SQUARE FEET: 14.97 SQ. FT.
 - SPRINGBOARD: 0.56 SQ. FT.
 - TOP: 6.08 SQ. FT.
 - POLE SHROUD: 8.33 SQ. FT.




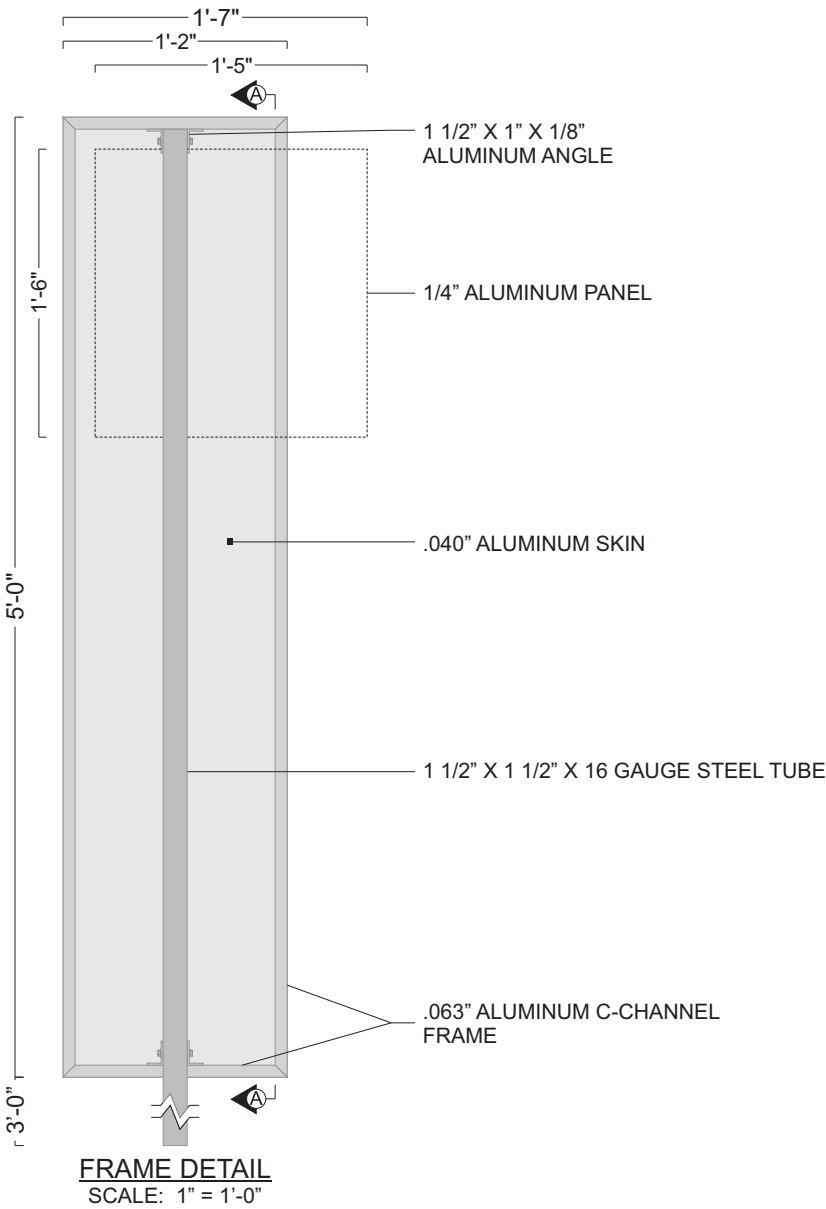
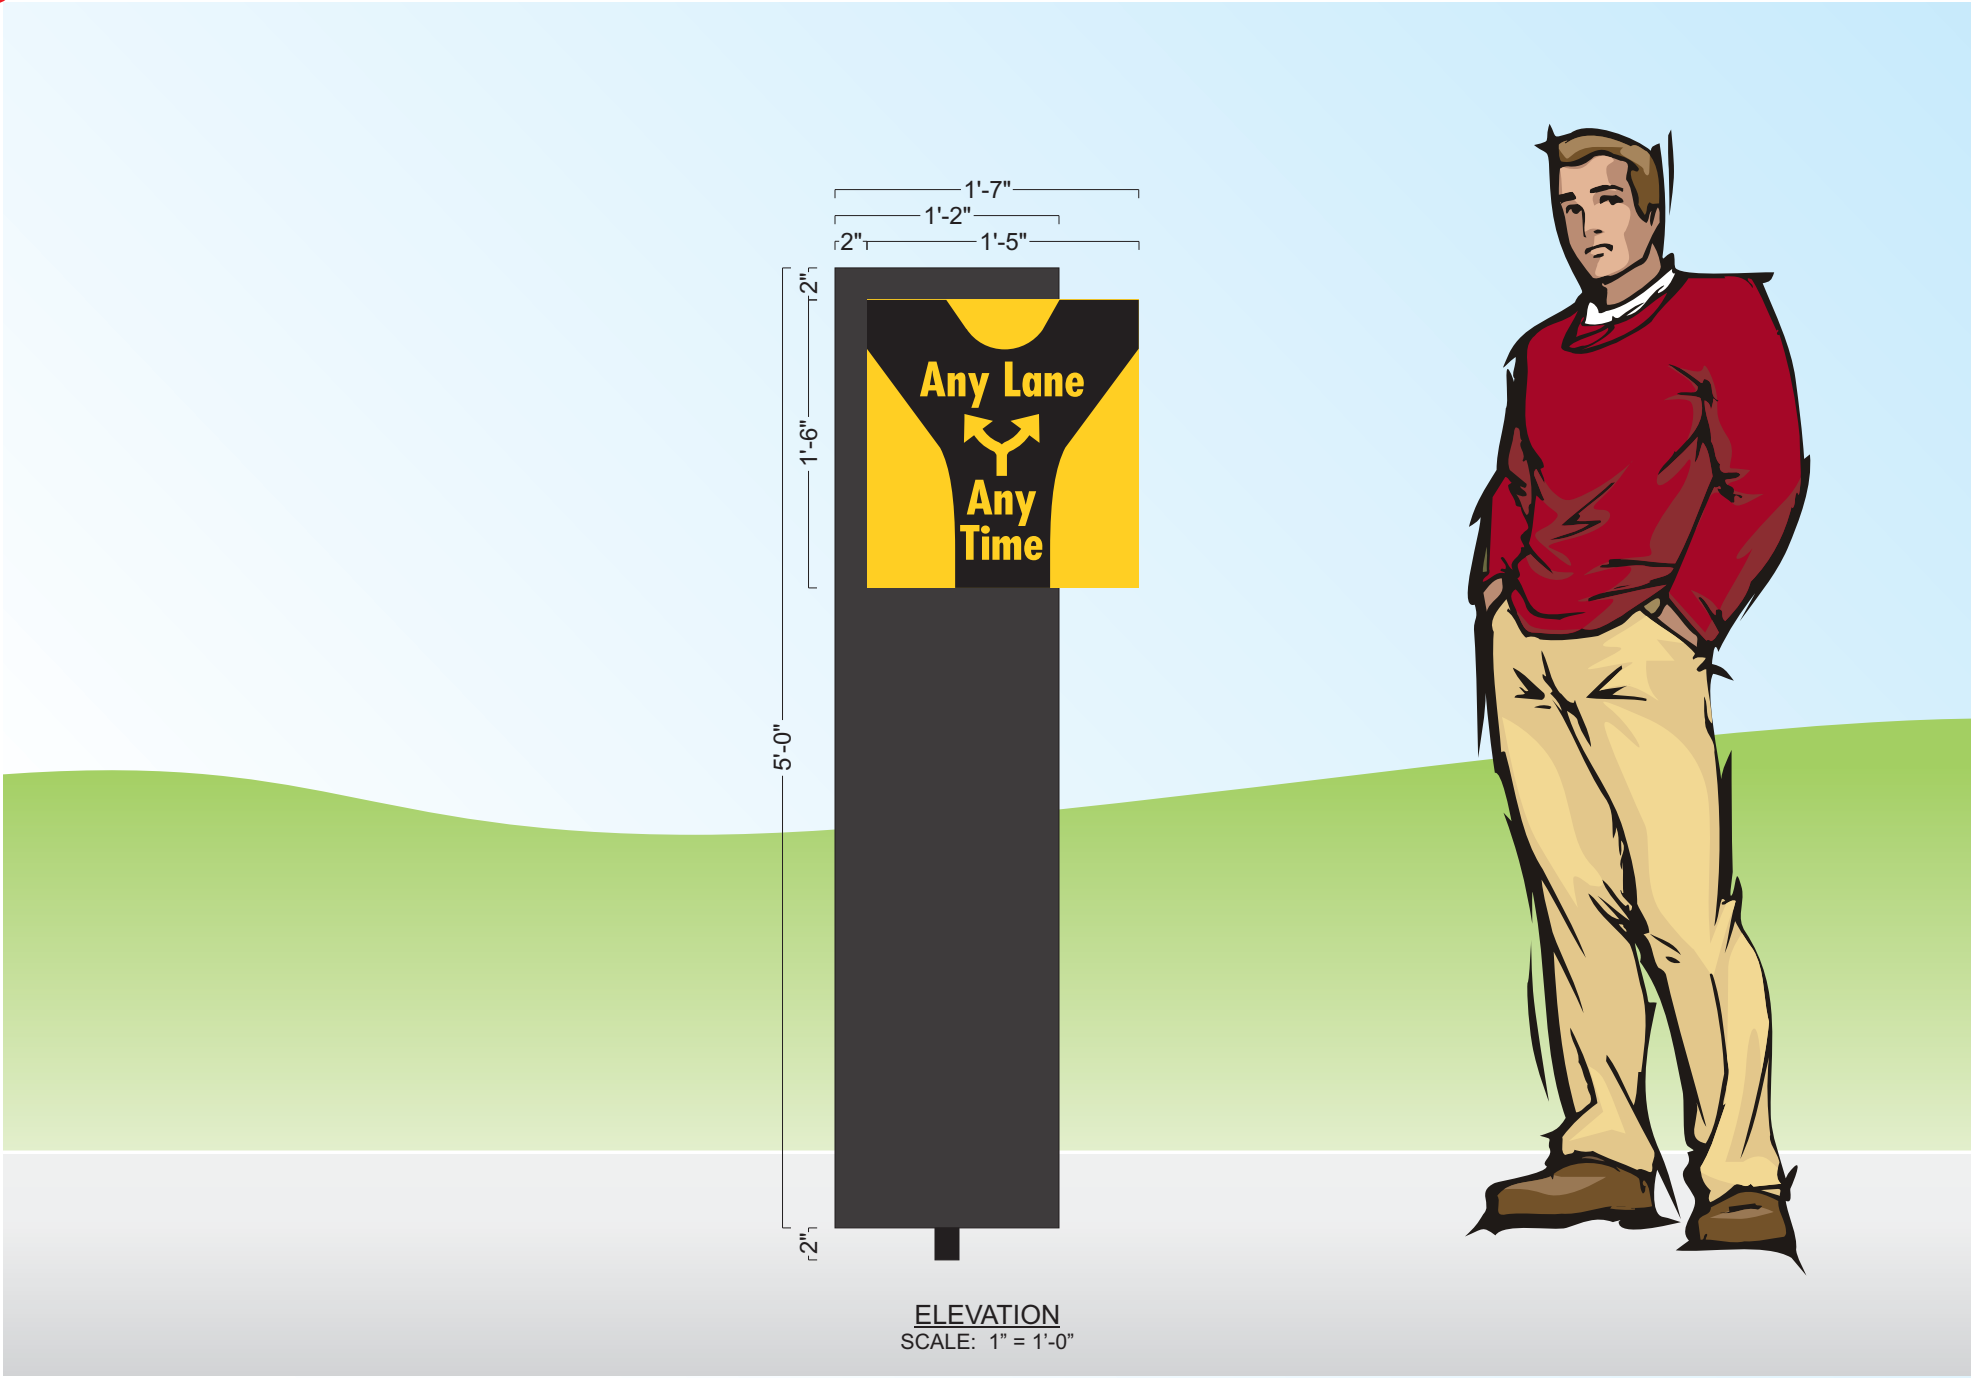


FRAME DETAIL
DESIGN FACTOR: TBD
1 1/2" X 3/4" X .063" ALUMINUM C-CHANNEL FRAME
.040" ALUMINUM SKINS
EXTERIOR FINISH: PAINT TO MATCH CHARCOAL ACM
SQUARE FOOTAGE: BOXED = 7.92, ACTUAL = 6.46

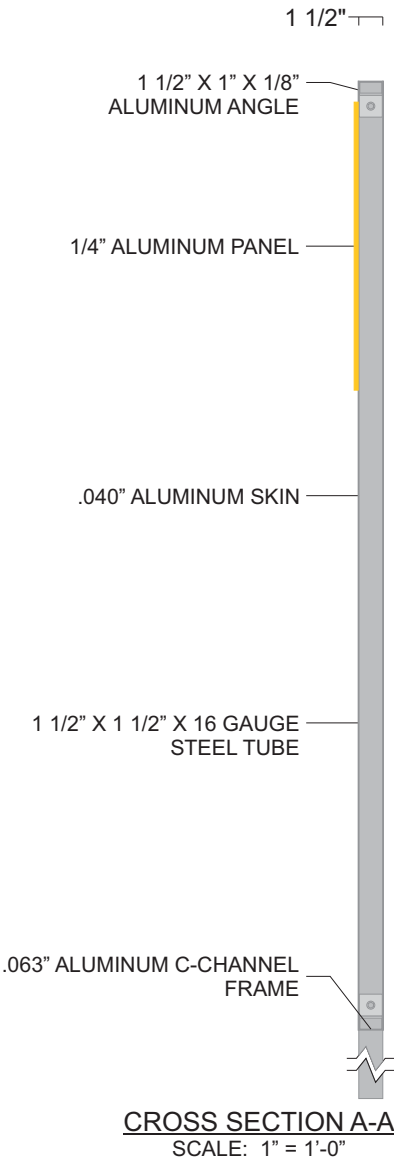

FACE DETAIL
1/4" ALUMINUM PANEL W/ 1ST SURFACE PAINT & VINYL DECO.:
MATCH PMS 123 GOLD - BACK-GROUND, COPY & ARROW
3630-22 BLACK - LANES



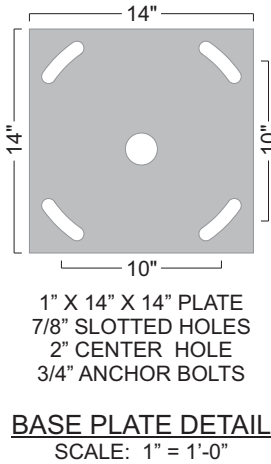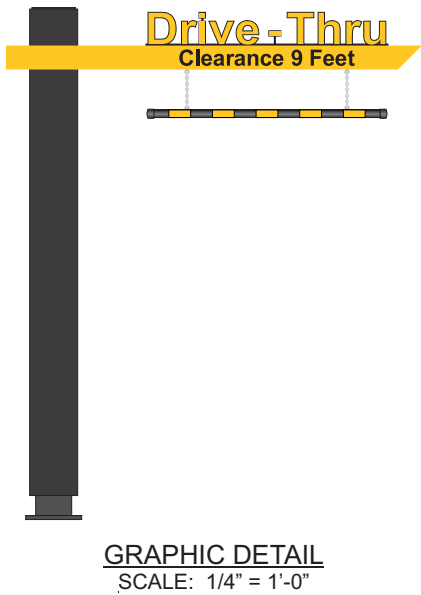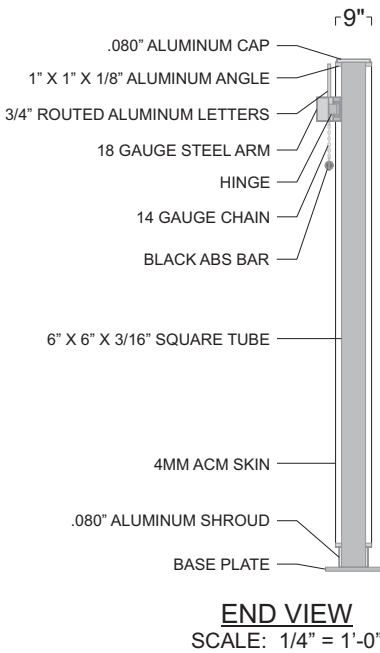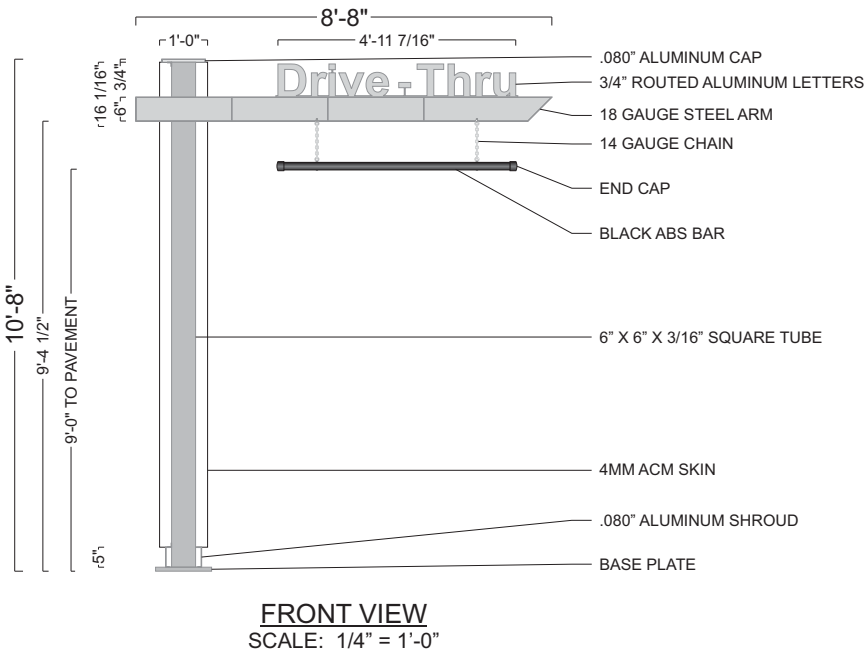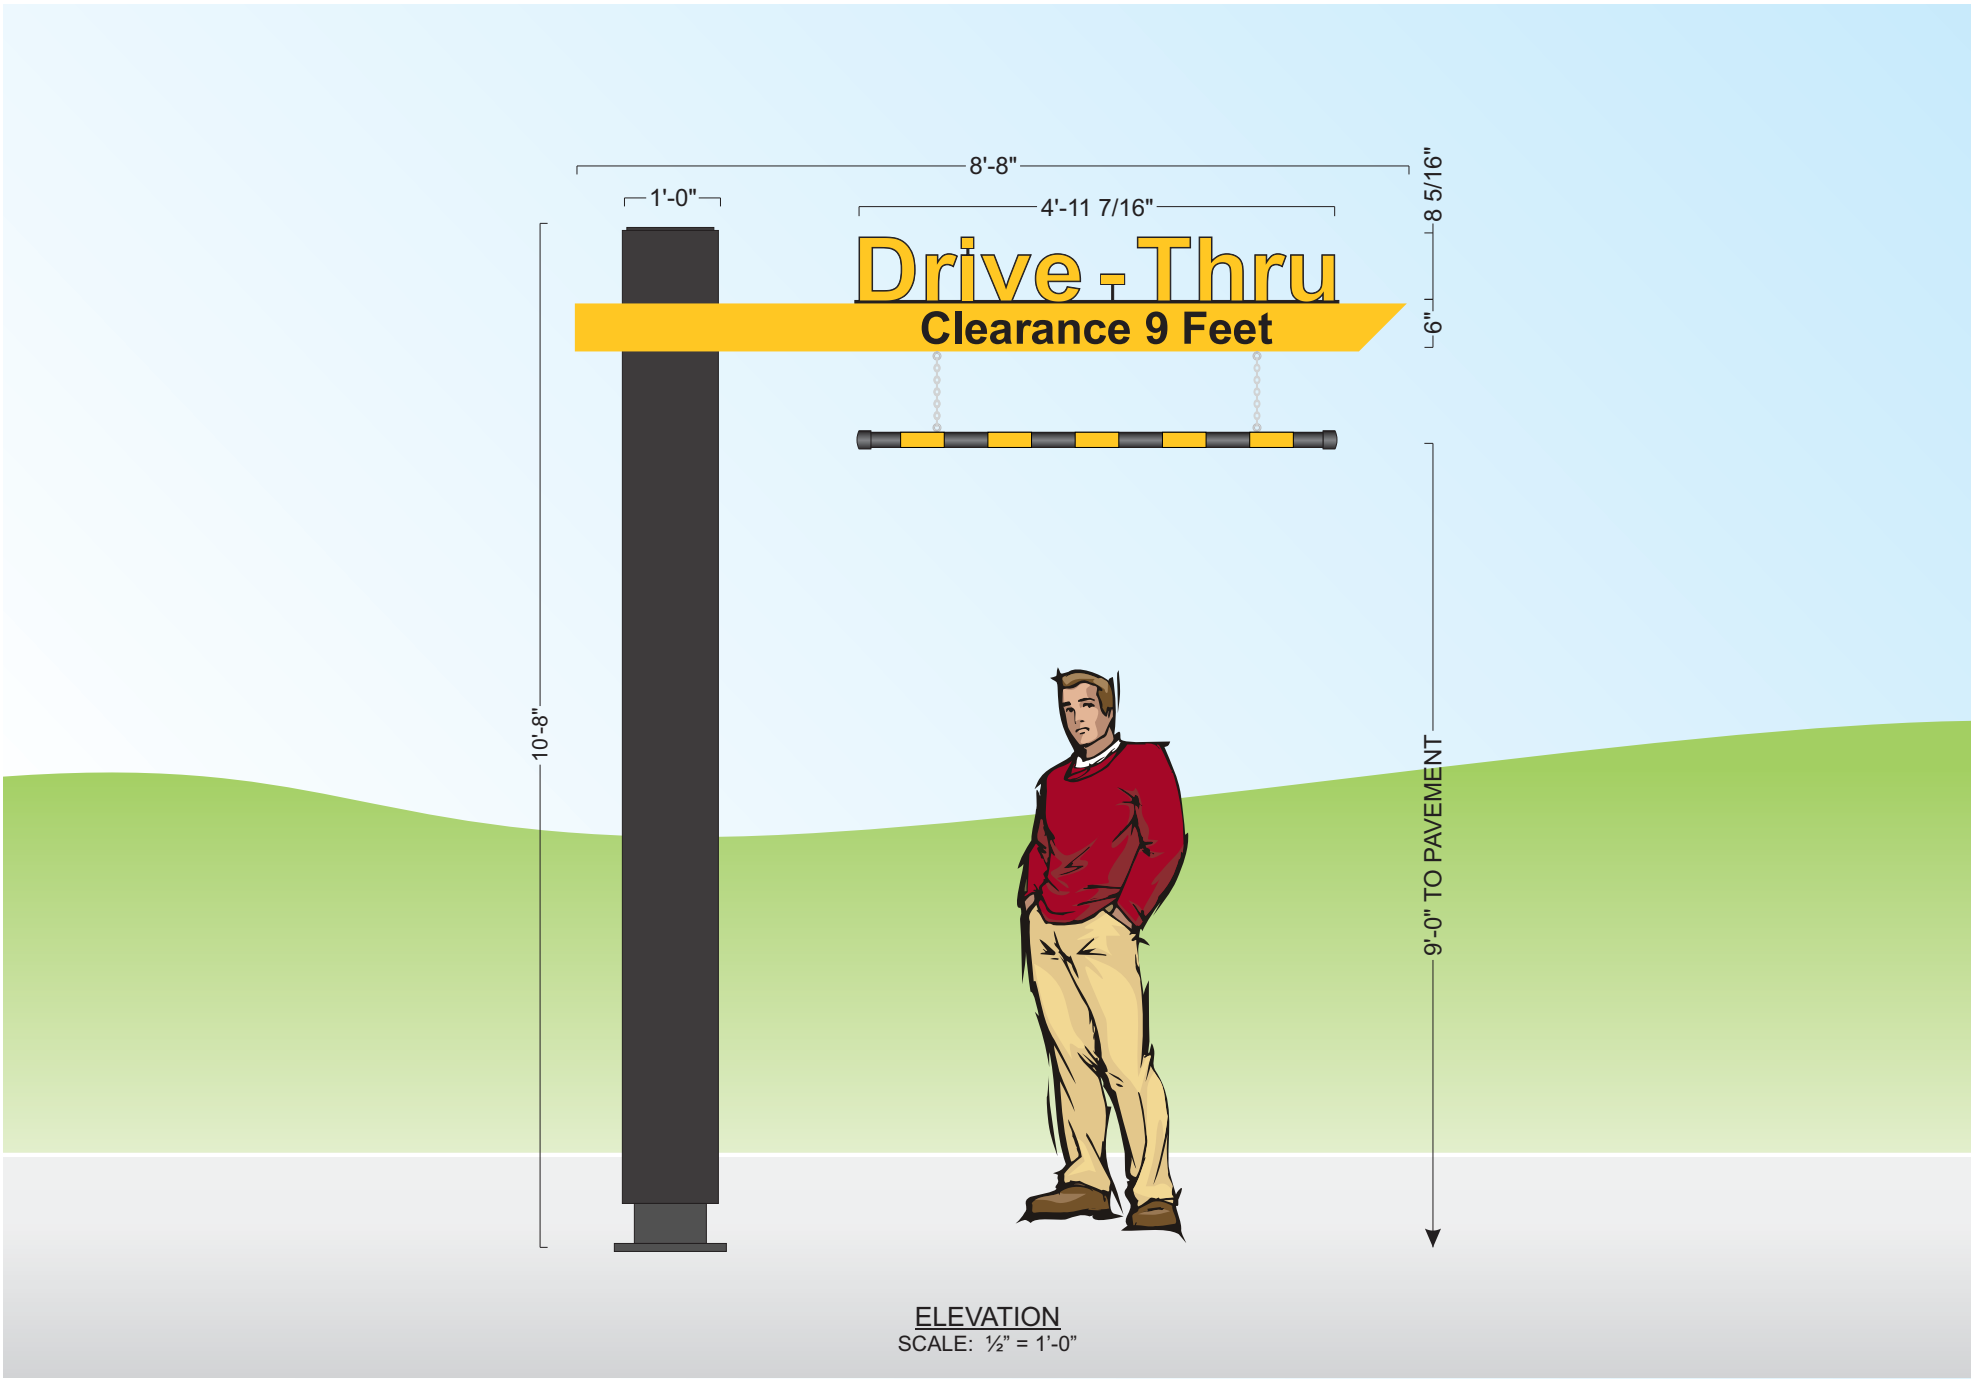




POLE COVER DETAIL
DESIGN FACTOR: TBD
4MM CHARCOAL ACM POLE COVER
.080" ALUMINUM CAP AND SHROUD
EXTERIOR FINISH:
POLE COVER - PRE-FINISHED CHARCOAL
SHROUD AND BASE PLATE - MATCH B.M. 1631 MIDNIGHT OIL

CLEARANCE BAR DETAIL
BLACK ACM PIPE W/ 180-25 GOLD VINYL STRIPES APPLIED TO 1ST SURFACE

SQUARE FEET: BOXED = 92.44
ACTUAL = 15.68


SWING ARM DETAIL
DESIGN FACTOR: TBD
18 GAUGE STEEL ARM WITH HINGE W/ 1ST SURFACE PAINT AND VINYL DECORATION:
MATCH PMS 123 C YELLOW - SWING ARM
7725-12 BLACK - "CLEARANCE 9 FEET" COPY

"DRIVE-THRU" LETTER DETAIL
3/4" ROUTED ALUMINUM LETTERS W/ 1ST SURFACE VINYL DECORATION:
180-25 GOLD - "DRIVE-THRU" COPY
BLACK - COPY OUTLINE

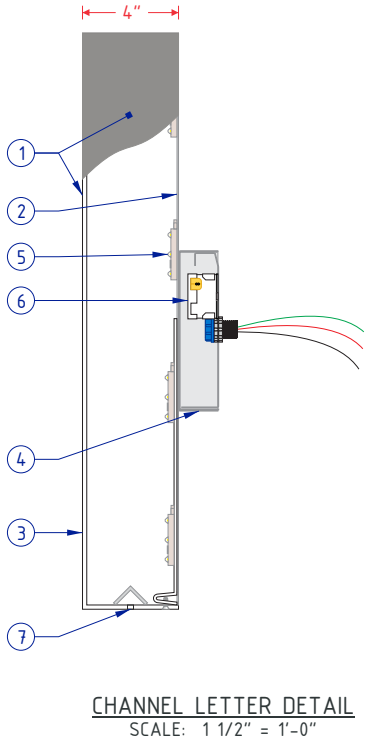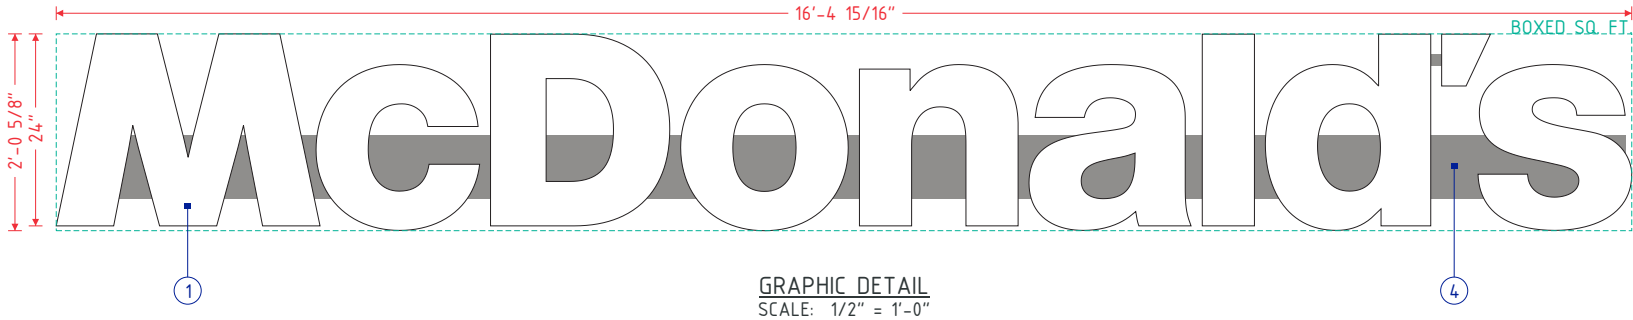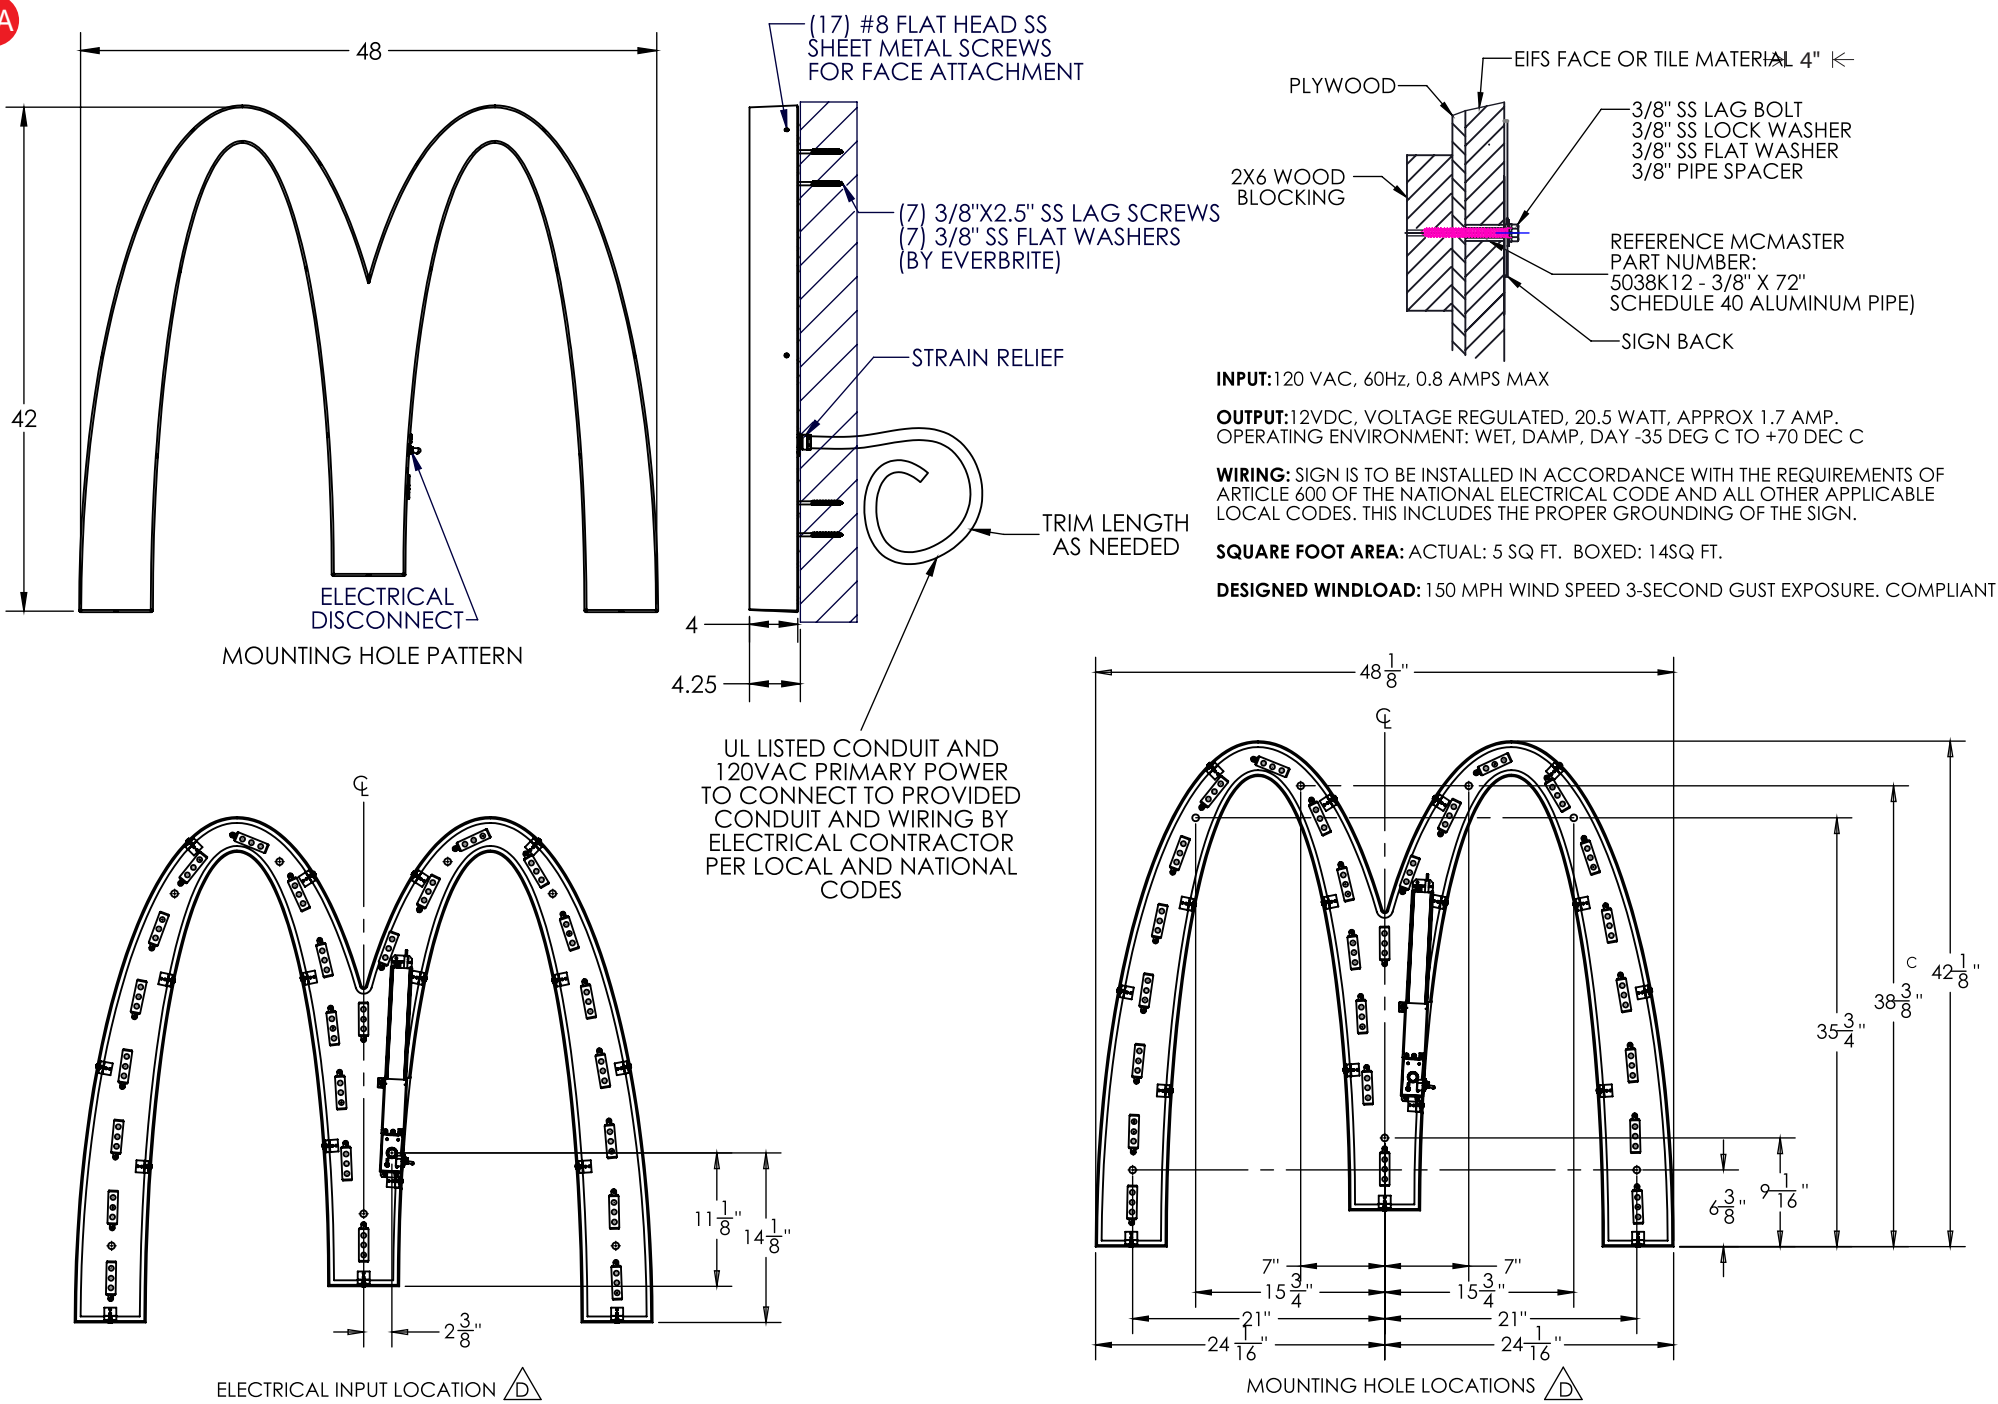

SPECIFICATIONS	
NO.	PART/DESCRIPTION
1	.177" MOLDED WHITE MODIFIED ACRYLIC FACES/LETTER BODIES WITH SIDES PAINTED MCDONALD'S SILVER (OPAQUE) ON EXTERIOR
2	.040" ALUMINUM BACKS
3	.118" WHITE ABS INSERTS
4	ALUMINUM RACEWAY PAINTED MCDONALD'S SILVER
5	GE 5000K WHITE LED'S AS REQUIRED
6	LED POWER SUPPLY LOCATED INSIDE RACEWAY
7	DRAIN HOLES WITH BAFFLES AS REQUIRED


- NOTES:
- LETTER INTERIORS TO BE WHITE
 - U.L. LISTED

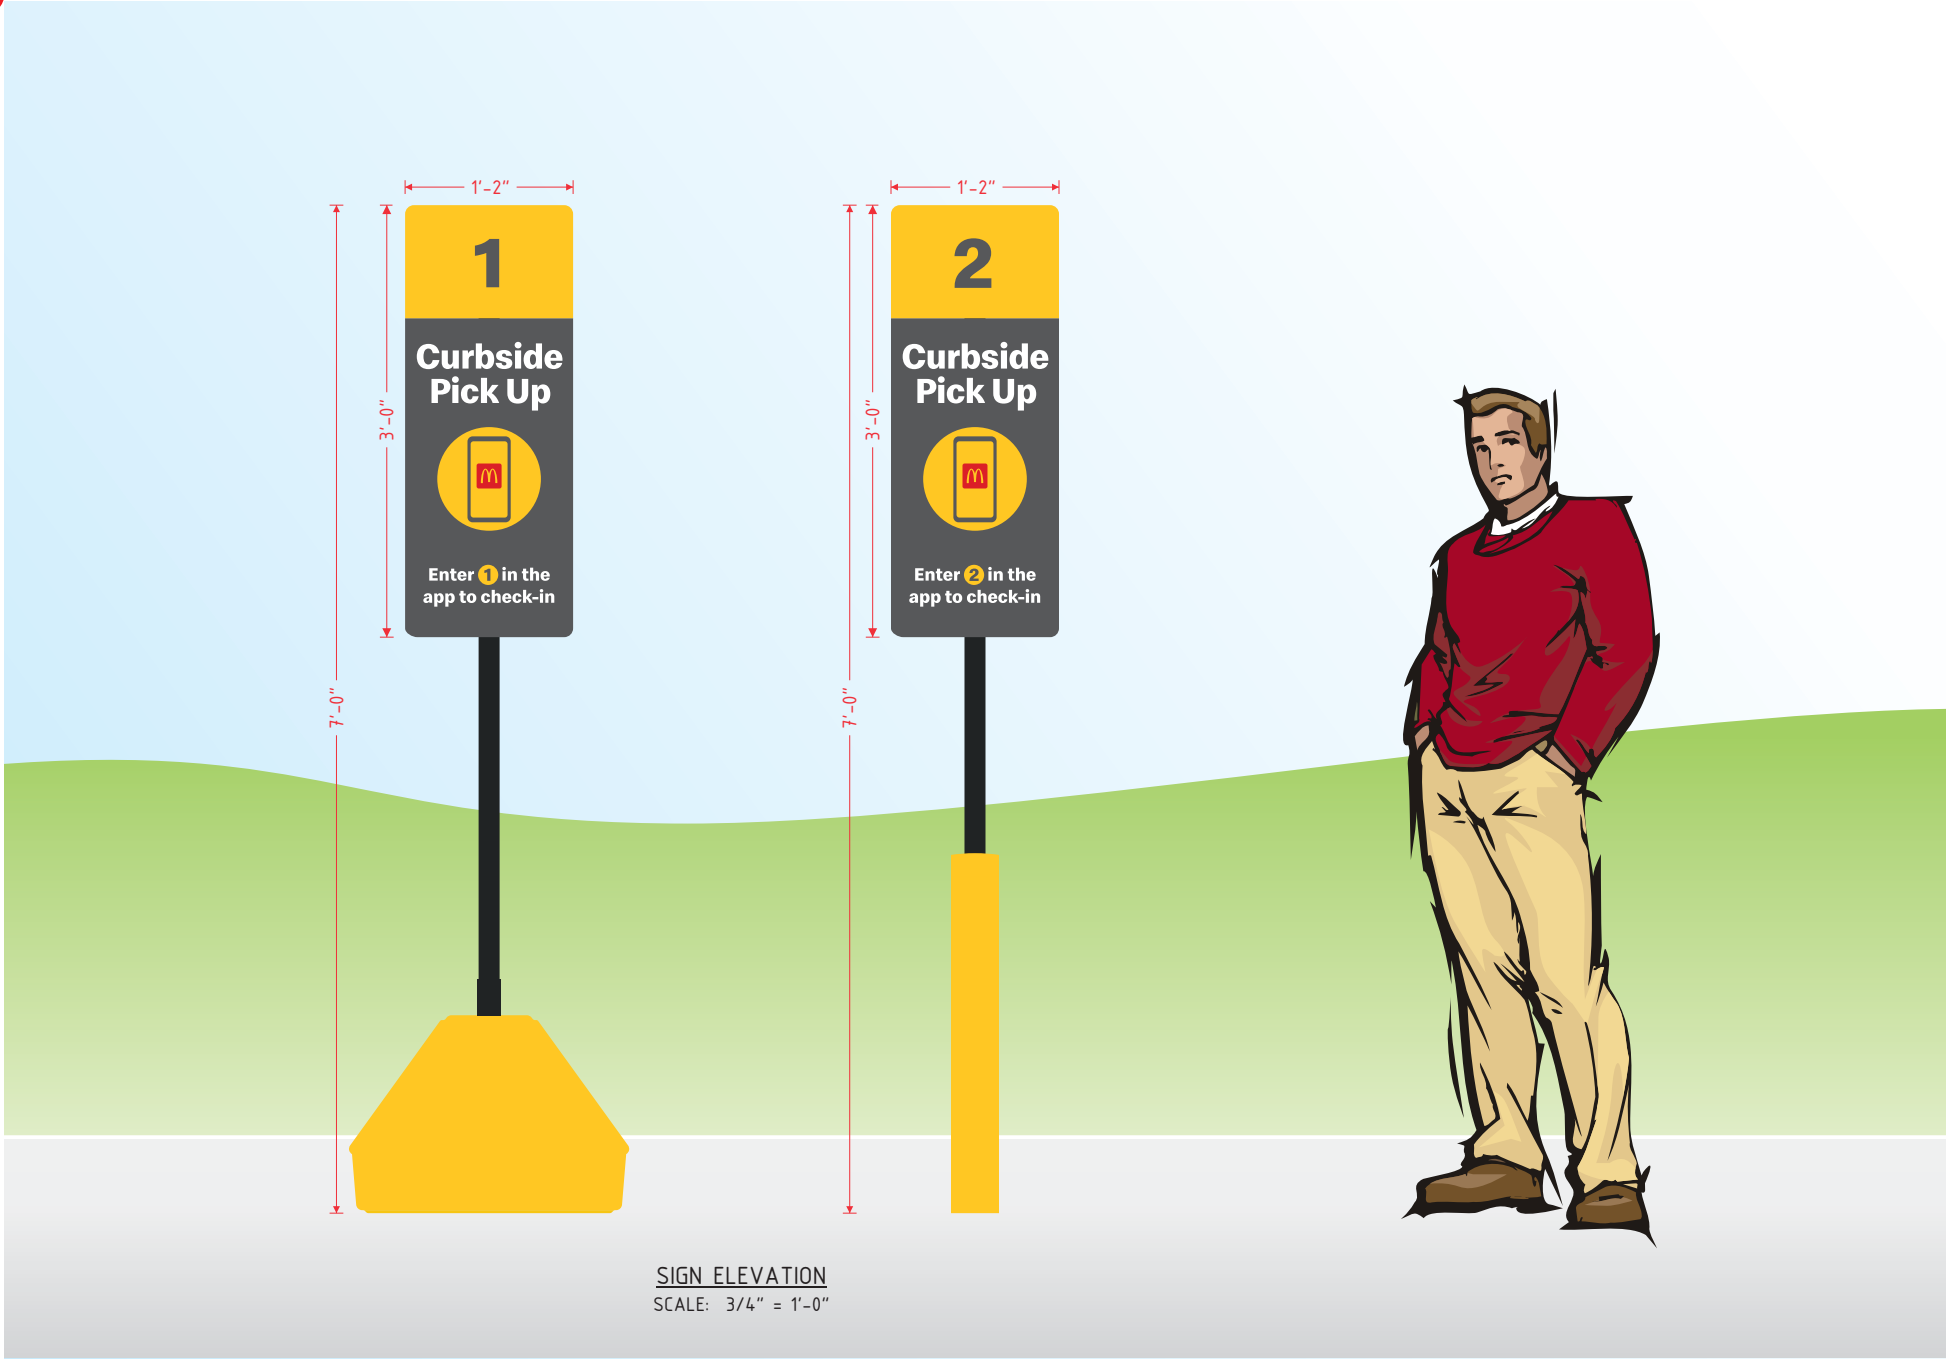


SIGN ELEVATION
SCALE: 3/4" = 1'-0"



GRAPHIC DETAIL
SCALE: 1 1/2" = 1'-0"

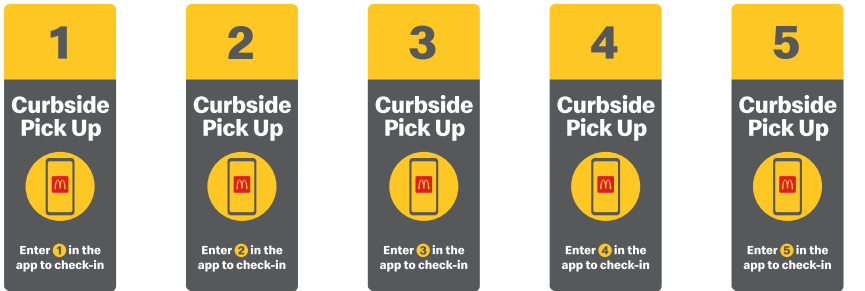



MCD22-MOCPU1-S2 MCD22-MOCPU2-S2 MCD22-MOCPU3-S2 MCD22-MOCPU4-S2 MCD22-MOCPU5-S2

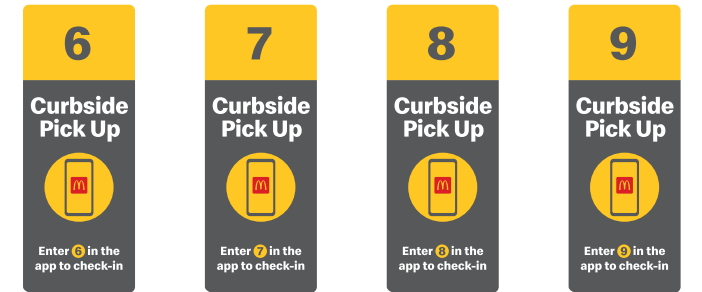

MCD22-MOCPU6-S2 MCD22-MOCPU7-S2 MCD22-MOCPU8-S2 MCD22-MOCPU9-S2



AVAILABLE FACES
SCALE: 1/2" = 1'-0"

MOBILE ORDER CURBSIDE PICKUP SIGN DETAIL
DESIGN FACTOR: TBD
4mm ACM PIGMENTED TO MATCH NG CHARCOAL
WHITE, YELLOW, & RED DIGITALLY PRINTED GRAPHICS
REFLECTIVE YELLOW VINYL NUMBER BACKGROUND
3.50 SQUARE FEET

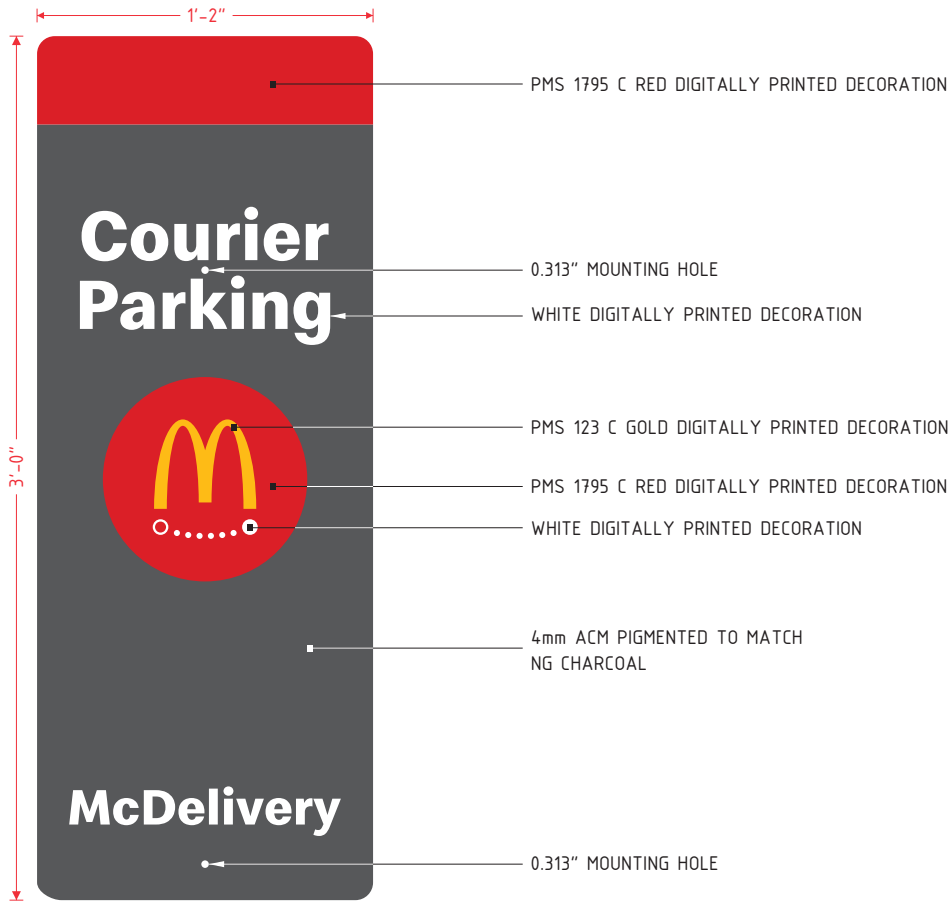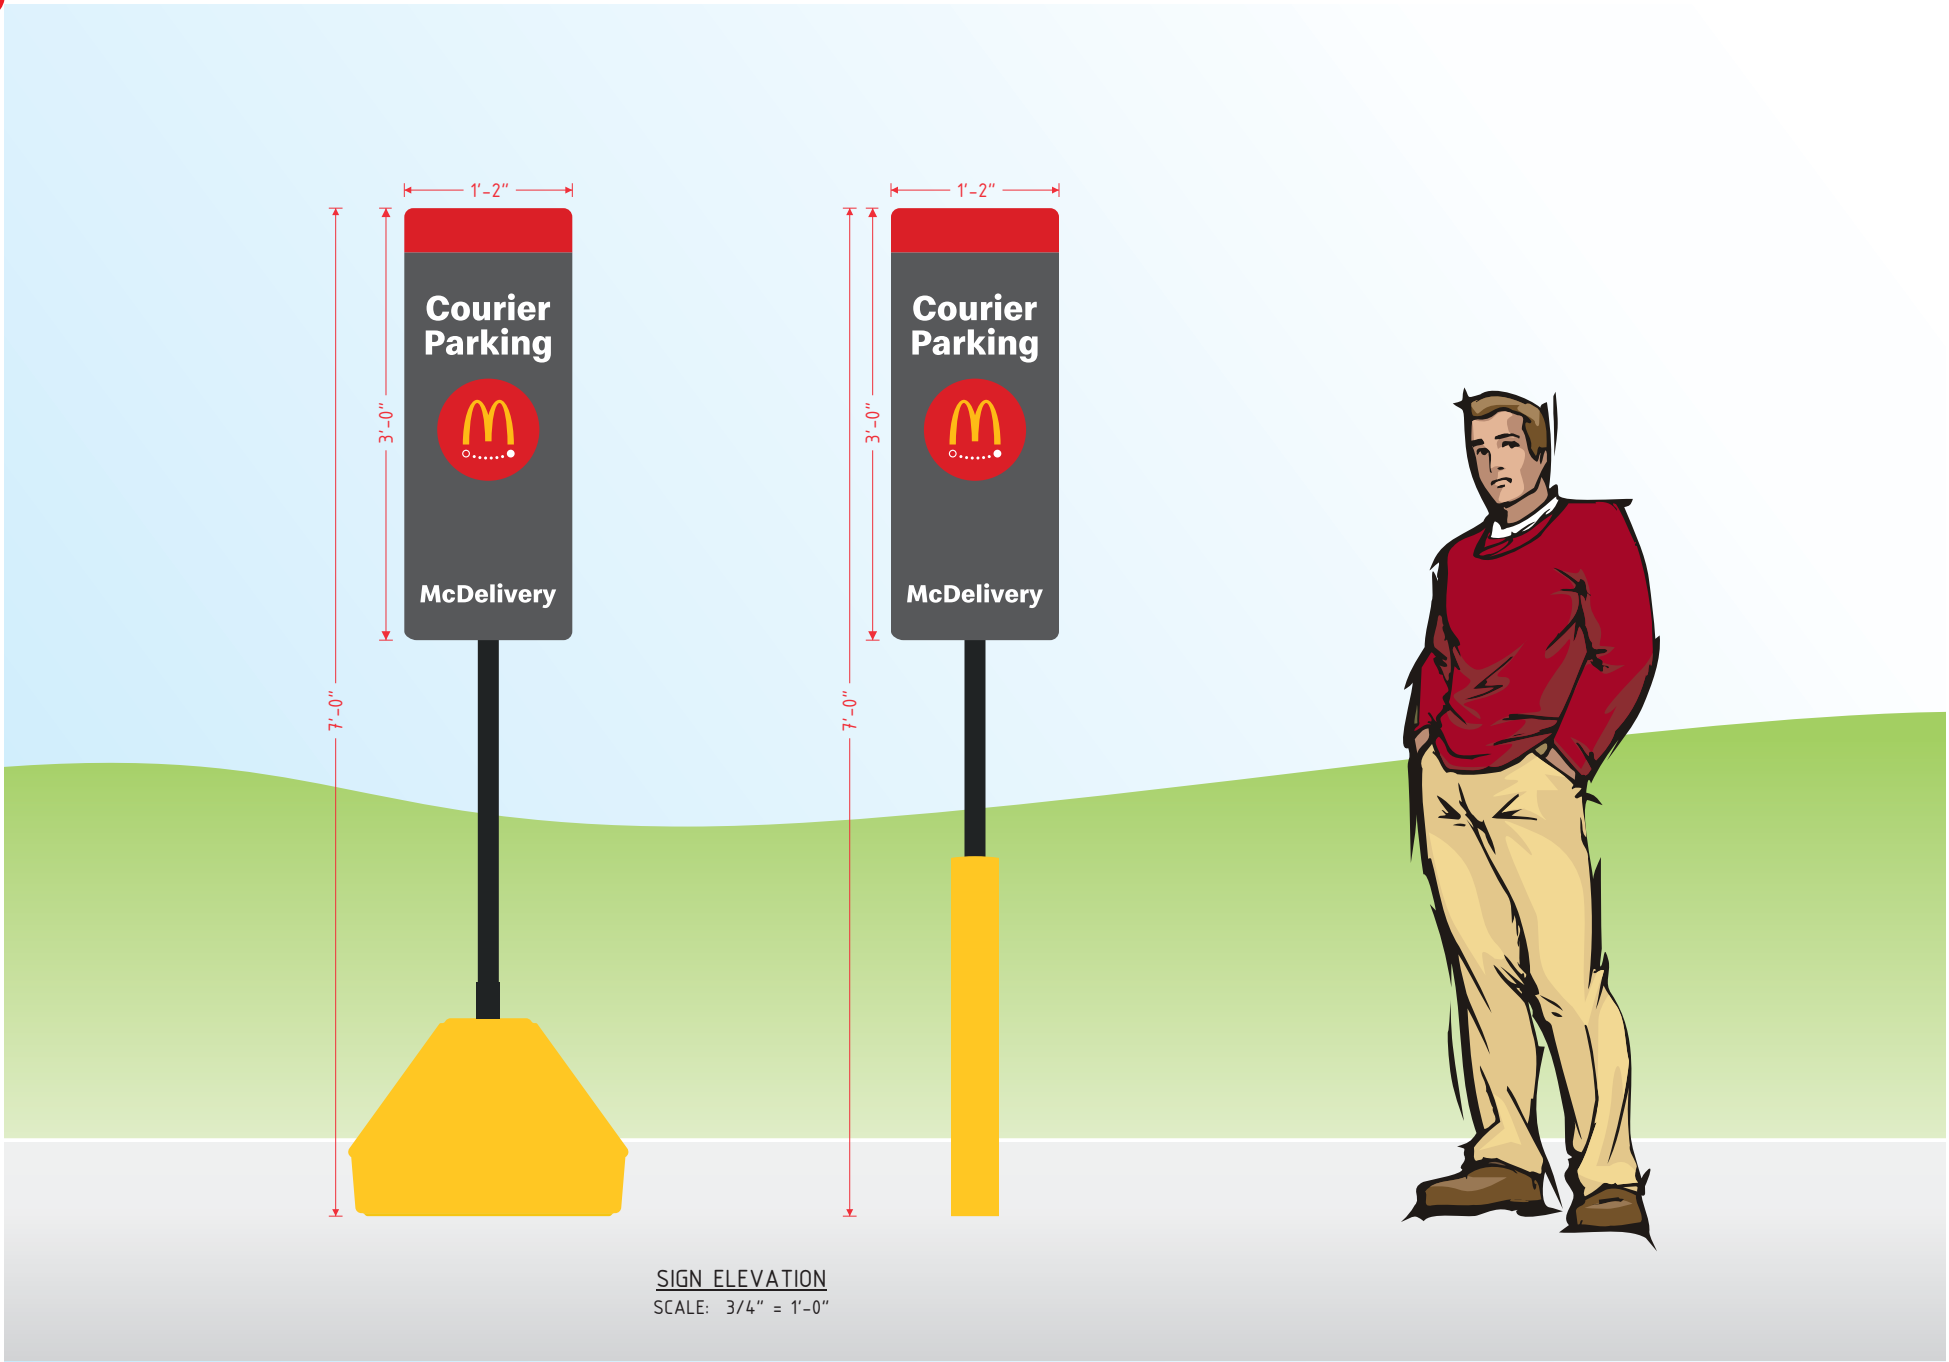

GRAPHIC DETAIL
SCALE: 1 1/2" = 1'-0"




COURIER PARKING SIGN DETAIL
DESIGN FACTOR: TBD
4mm ACM PIGMENTED TO MATCH NG CHARCOAL
WHITE, YELLOW, & RED DIGITALLY PRINTED GRAPHICS
REFLECTIVE YELLOW VINYL NUMBER BACKGROUND
3.50 SQUARE FEET

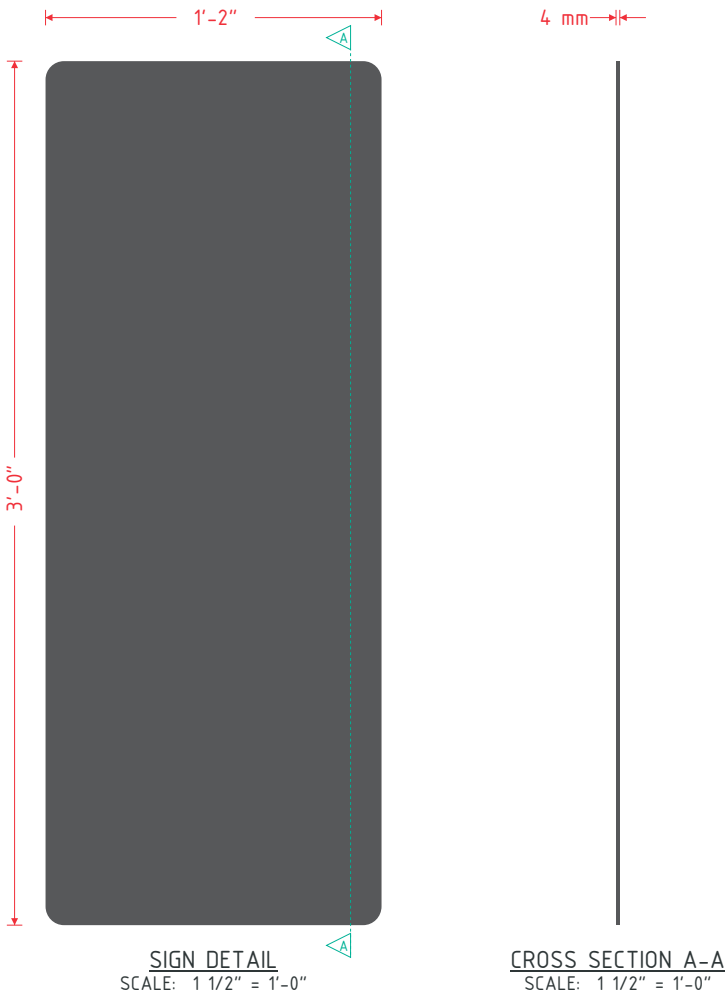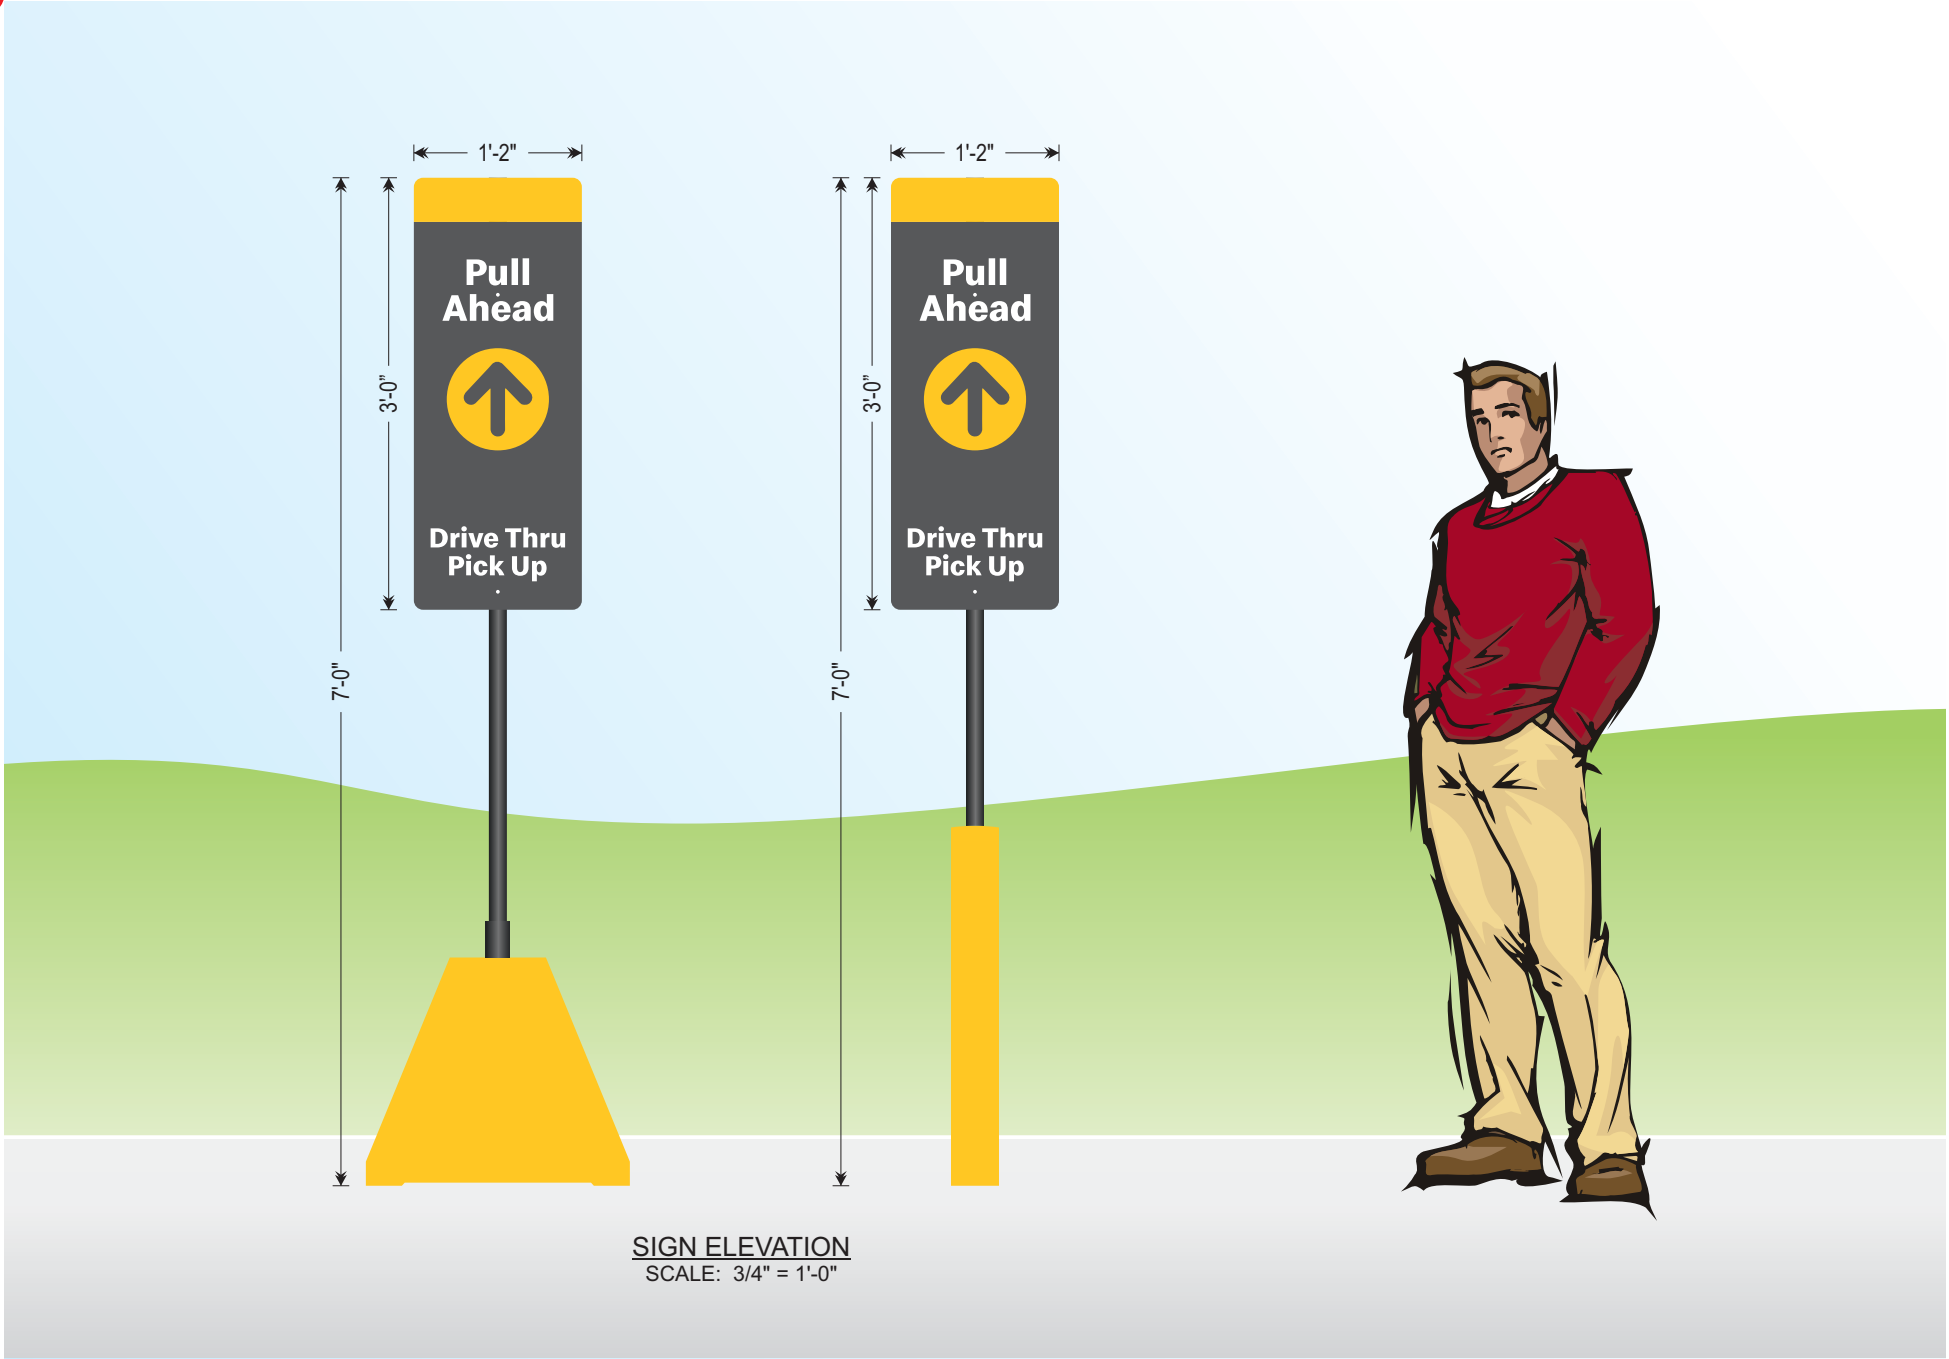

- SPECIFICATIONS
- 4MM NG CHARCOAL ACM
 - DIGITALLY PRINTED DECORATION (1ST SURFACE) TO MATCH:
 - PMS 123 C YELLOW
 - WHITE



GRAPHIC DETAIL
SCALE: 1" = 1'-0"

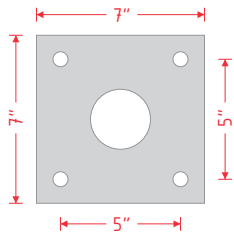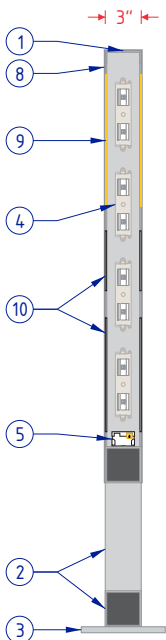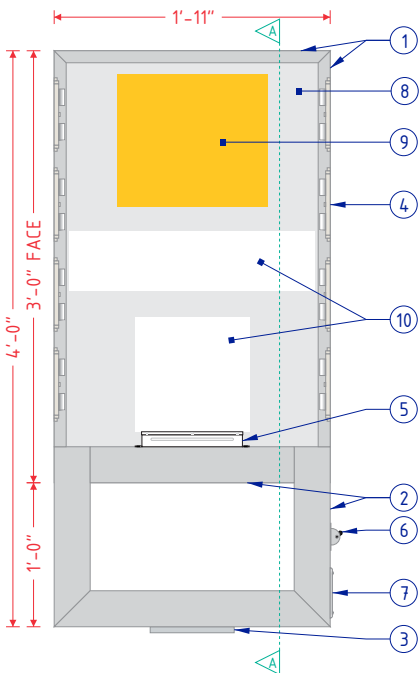





1/2" X 7" X 7" ALUMINUM PLATE
5/8" BOLT HOLES
2 1/2" CENTER HOLE

PLATE DETAIL
SCALE: 1 1/2" = 1'-0"

MCDONALD'S 48" NEXT GEN DIRECTIONAL SPECIFICATIONS	
NO.	PART/DESCRIPTION
1	3" X 1" X 1/8" ALUMINUM C-CHANNEL
2	3" X 3" X 1/8" ALUMINUM TUBE
3	MOUNTING PLATE (SEE PLATE DETAIL)
4	WHITE LED'S AS REQUIRED
5	LED POWER SUPPLIES AS REQUIRED
6	DISCONNECT SWITCH
7	ELECTRICAL CONNECTION ACCESS THROUGH COVER
8	.080" ROUTED ALUMINUM SHOEBOX FACES
9	.118" NG YELLOW SOLAR GRADE POLYCARBONATE BACKER PANEL
10	.118" NG WHITE SOLAR GRADE POLYCARBONATE BACKER PANEL
11	POWDERCOAT HENTZEN #P90353APC (OR PAINT TO MATCH)
12	PAINT TO MATCH SILVER OR METALLIC GRAY

NOTES:

- DESIGN FACTOR: TO BE DETERMINED
- 3" X 1/8" ALUMINUM C-CHANNEL FRAME
- ROUTED ALUMINUM SHOTEBOX FACES
- EXTERIOR FINISH:
 - FACES - POWDERCOAT HENTZEN #P90353APC (OR PAINT TO MATCH)
 - TUBES AND PLATE - PAINT SILVER OR METALLIC GRAY
- INTERIOR FINISH: PAINT REFLECTIVE WHITE
- FACES REMOVABLE FOR SERVICE ACCESS
- U.L. LISTED
- ELECTRICAL: 1.10 AMPS/120 VOLTS
- SQUARE FOOTAGE:
 - FACE = 5.75
 - DISPLAY = 7.67

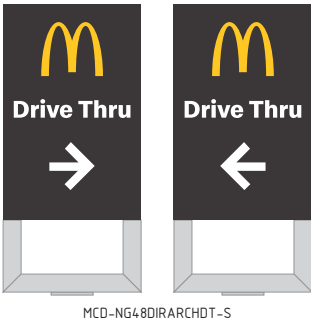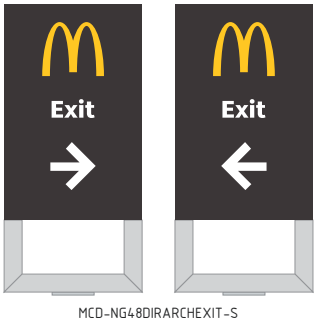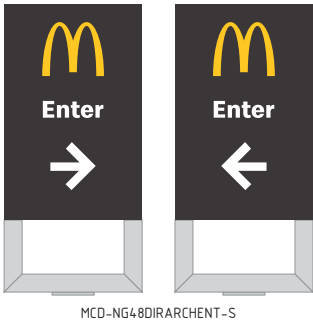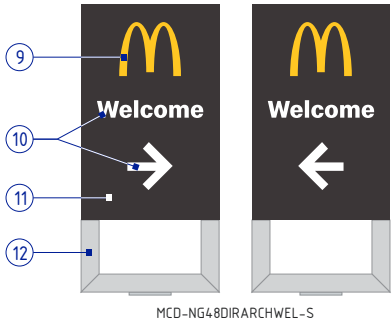

GRAPHIC DETAIL
SCALE: 3/8" = 1'-0"





This sign is intended to be installed in accordance with the requirements of Article 600 of the National Electric Code and/or other applicable local codes. This includes proper grounding and bonding of the sign.


This is an original document created by Persona Signs, LLC provided specifically to the client for the client's personal use. This document should not be shared, reproduced, disclosed or otherwise used without written permission from Persona Signs, LLC.

Customer Approval (Please Initial):

Approval Date:

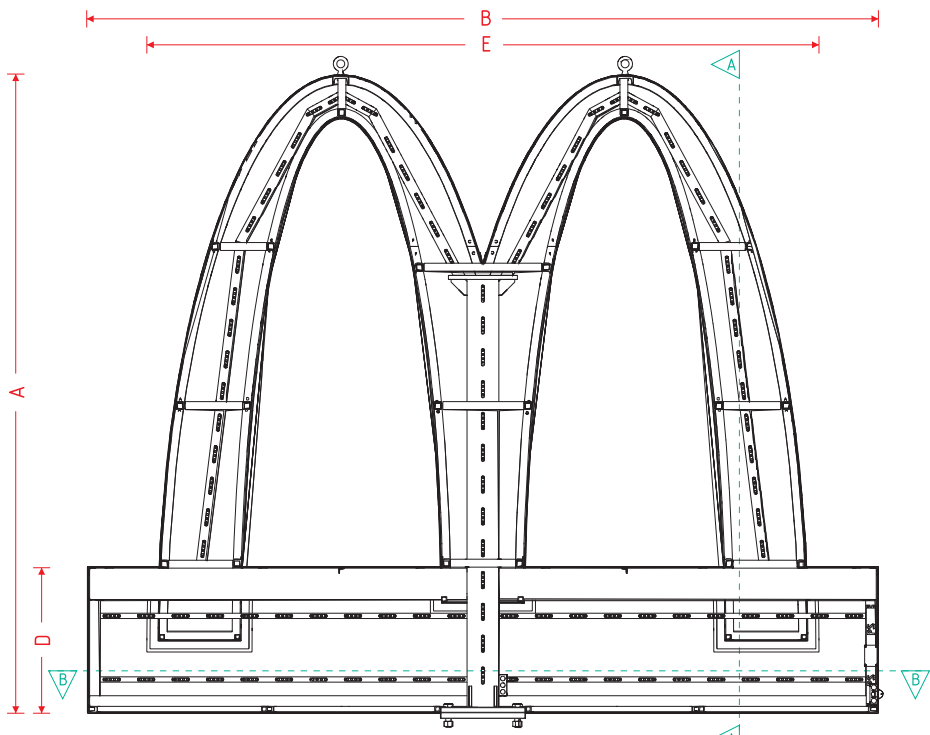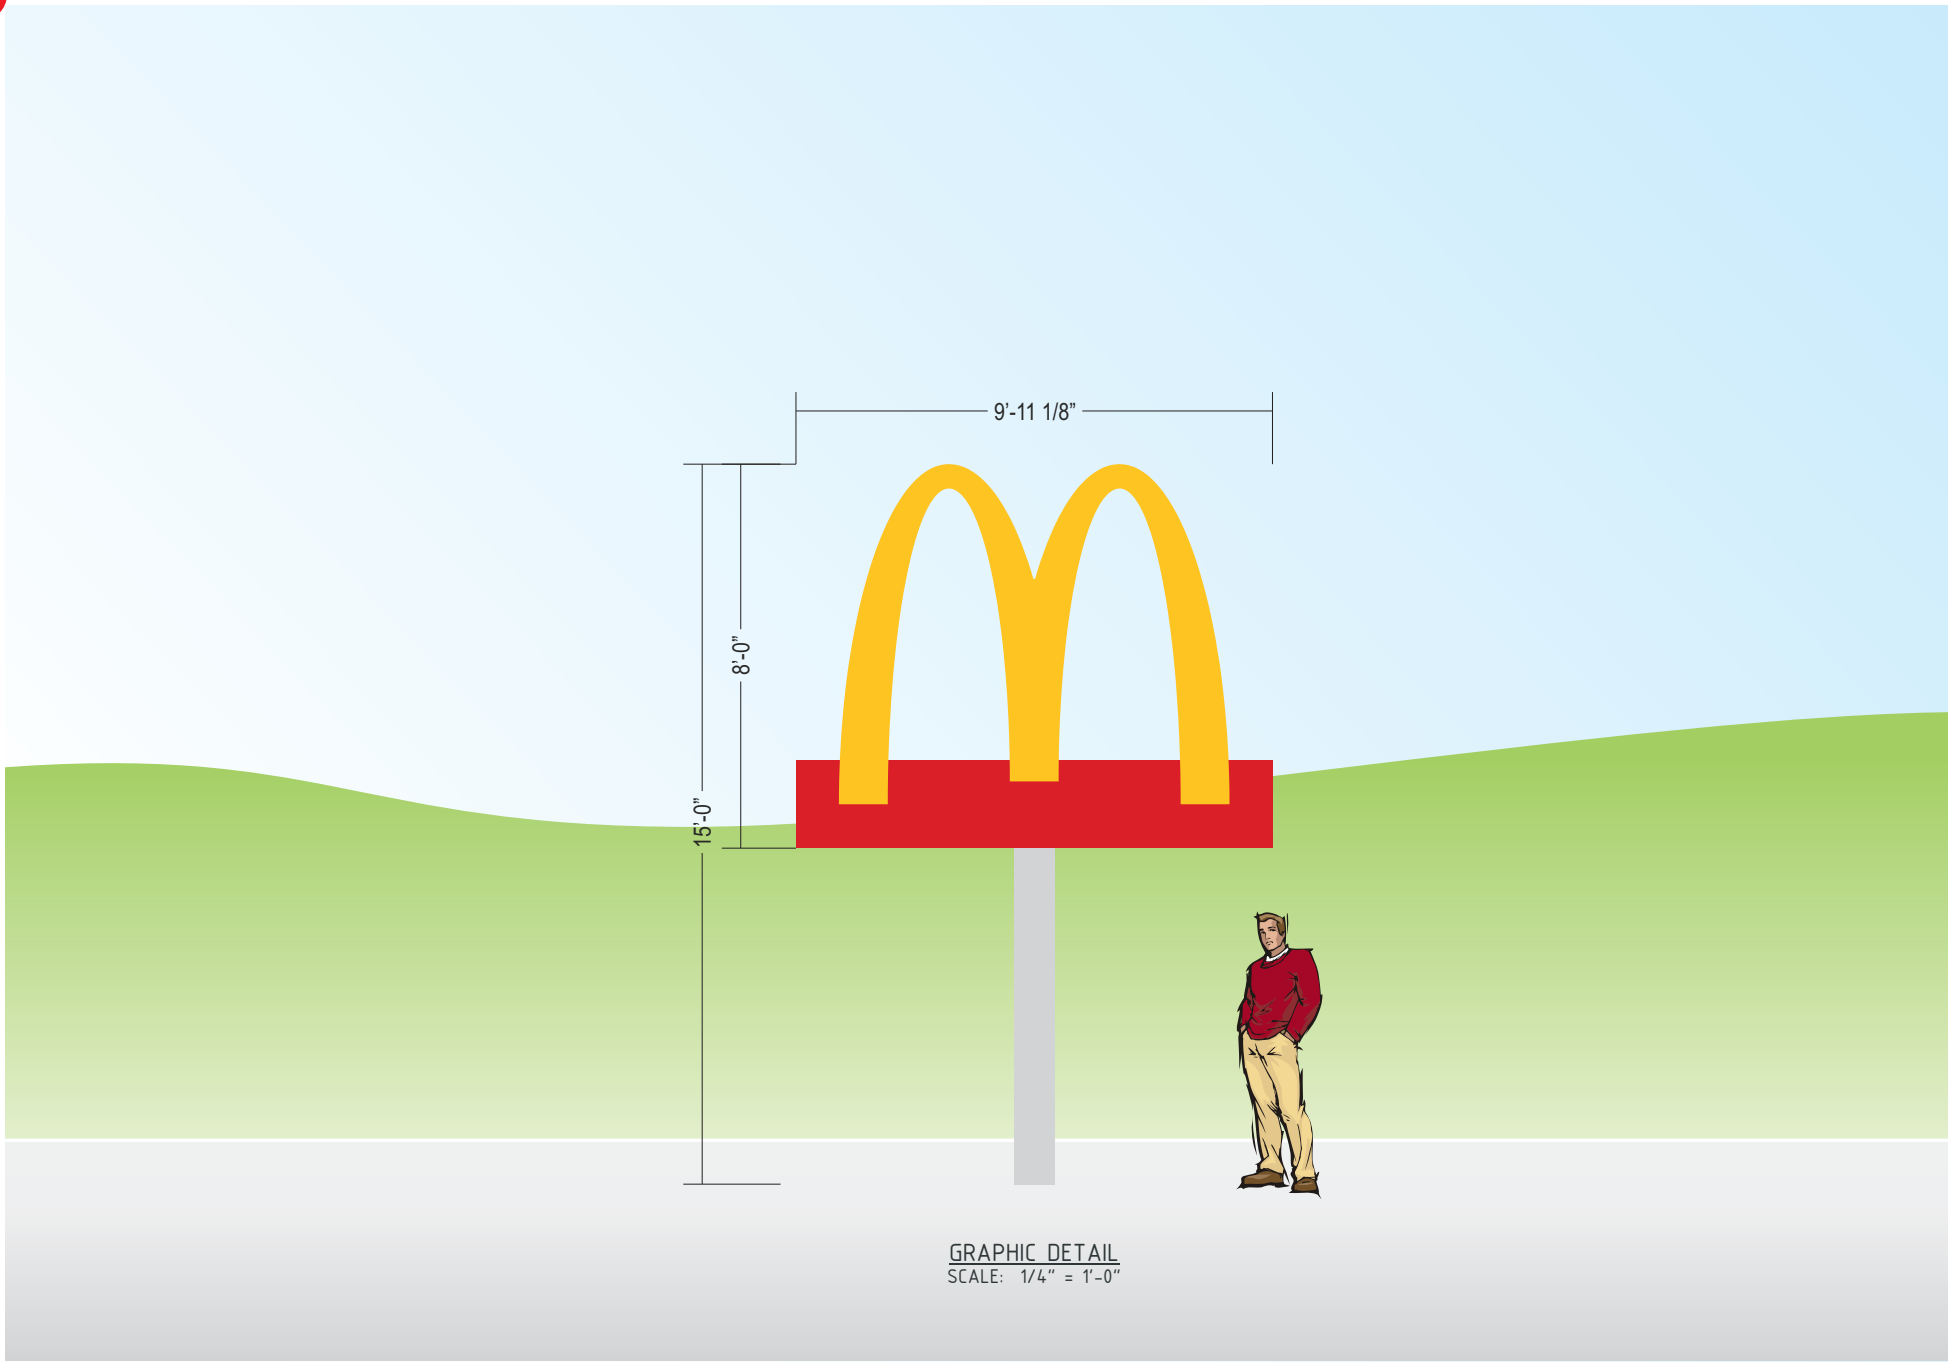

FRAME & LIGHTING DETAIL
NOT TO SCALE

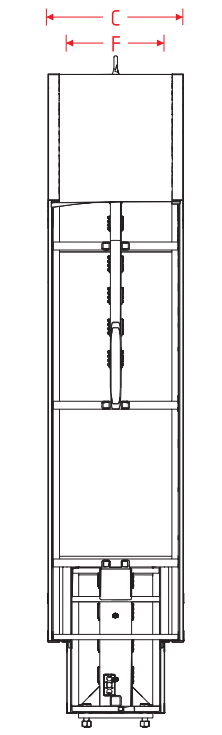


CROSS SECTION A-A
NOT TO SCALE

- SPECIFICATIONS
- STEEL SQUARE TUBE FRAME
 - FLAT ALUMINUM RETAINERS
 - EXTERIOR FINISH:
 - ARCH FRAME: PAINT TO MATCH NG YELLOW
 - KEYSTONE FRAME: PAINT TO MATCH NG RED
 - INTERIOR FINISH: PAINT REFLECTIVE WHITE
 - U.L. LISTED
 - DISCONNECT SWITCH LOCATED AT END OF KEYSTONE CABINET
 - 24 GA SKINS
 - RETAINERS REMOVABLE FOR SERVICE ACCESS
 - GE 5000K WHITE LED'S AS REQUIRED
 - ARCH FACE: .118" NG YELLOW POLYCARBONATE 1/2" EMBOSSED FACE (UNDER RETAINER)
 - KEYSTONE FACE: .150" NG RED POLYCARBONATE 1/2" EMBOSSED FACE (UNDER RETAINER)
 - PLATE/MATCH PLATE INSTALLATION
 - * MATCH PLATE TO BE ORDERED SEPARATELY



GRAPHIC DETAIL
NOT TO SCALE

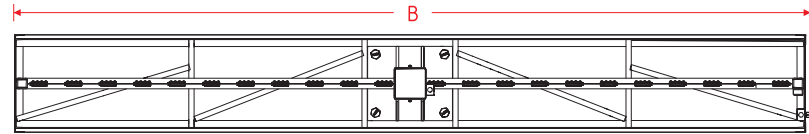

CROSS SECTION B-B
NOT TO SCALE

ITEM	OVERALL HEIGHT	OVERALL LENGTH	ARCH DEPTH	KEYSTONE HEIGHT	ARCH LENGTH	KEYSTONE DEPTH	ARCH FACE PIECES	MOUNTING PLATE	MAX PIPE / TUBE OD SIZE	ELECTRICAL	BOXED SQ FT	ACTUAL SQ FT
	A	B	C	D	E	F						
MCD20-5X6DRHWYSGN-S	5'-2"	6'-4 15/16"	1'-7 3/8"	1'-2 3/16"	5'-3 1/16"	1'-1 9/16"	1	10" X 10" X 3/4"	6 5/8" / 6"	(1) 20A / 120V CIRCUIT	33.13	16.34
MCD20-8X9DRHWYSGN-S	8'-0"	9'-11 1/8"	1'-7 3/8"	1'-9 15/16"	8'-1 5/8"	1'-1 9/16"	4	11" X 15" X 3/4"	10 3/4" / 10"	(1) 20A / 120V CIRCUIT	79.42	39.17
MCD20-10X12DRHWYSGN-S	10'-0"	12'-4 15/16"	2'-0 3/16"	2'-3 7/16"	10'-2 1/16"	1'-4 15/16"	4	14" X 16" X 1"	12 3/4" / 10"	(1) 20A / 120V CIRCUIT	124.11	61.2
MCD20-11X14DRHWYSGN-S	11'-6"	14'-3 1/4"	2'-9 7/8"	2'-7 9/16"	11'-8 3/8"	2'-0"	4	21" X 21" X 1"	14" / 14"	(1) 20A / 120V CIRCUIT	164.11	80.94