


NOTE: FOOTCANDLE LEVELS SHOWN ON PLAN REFLECT ILLUMINATION FROM AMBIENT CEILING FIXTURES ONLY. CONTRIBUTION FROM DECORATIVE PENDANTS, CHANDELIERS, WALL SCONCES, OR TRACK LIGHTING NOT SHOWN.

NOTE: PENDANT LOCATIONS SHOWN ON PLAN ARE LOCATED BY SEATING AND DECOR COMPANY AND ARE SUBJECT TO CHANGE BASED ON FINAL SEATING LAYOUT. SPECIFIC DECORATIVE FIXTURE SELECTION BY SEATING AND DECOR COMPANY OR OWNER/OPERATOR.

NOTE: FIXTURE QUANTITIES AND LOCATIONS MAY VARY DEPENDING UPON FINAL REFLECTED CEILING PLAN/FURNITURE LAYOUT AS DETERMINED BY OTHERS.

REFERENCE DÉCOR DRAWINGS FOR L04 DIRECTIONAL PLACEMENT.

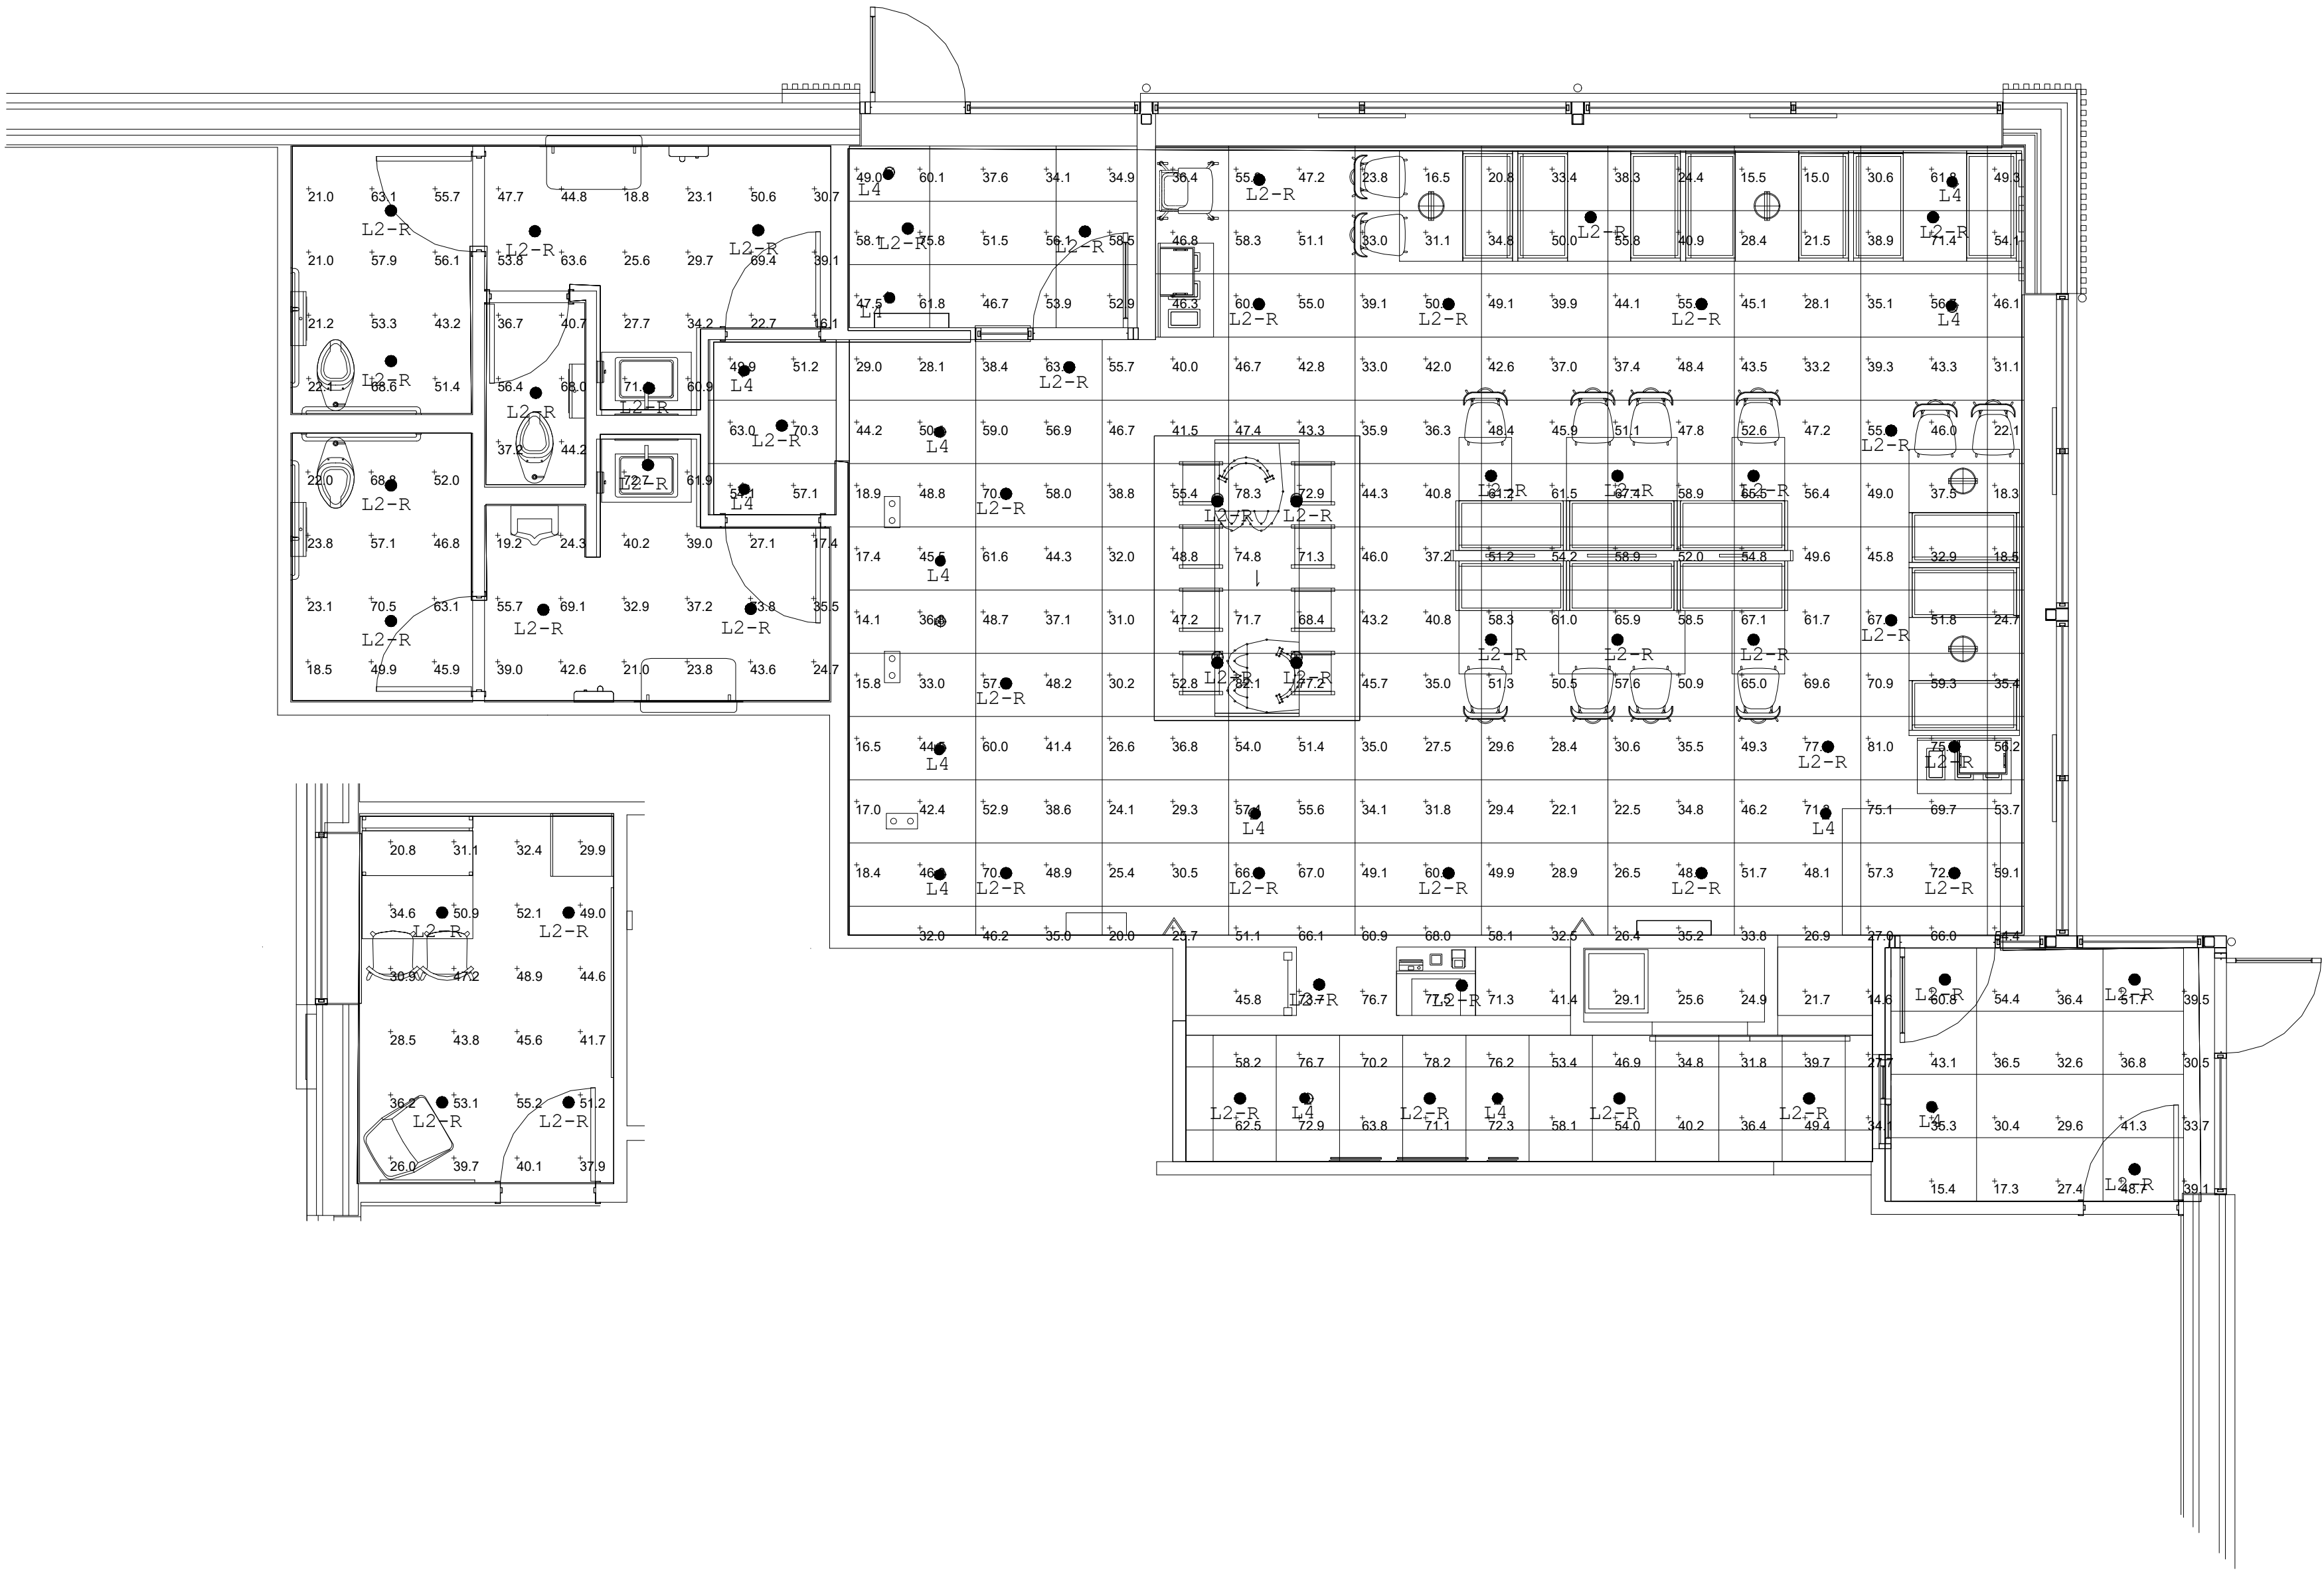

Luminaire Schedule					
Symbol	Qty	Label	Description	LLF	Luminaire Watts
⊕	55	L2-R	RDA-136LM-30-FL-S	0.900	16.1
⊕	15	L4	RDA-60LM-30-NF	0.900	7.02

Calculation Summary							
Label	CalcType	Units	Avg	Max	Min	Avg/Min	Max/Min
Crew Workplane	Illuminance	Fc	40.48	55.2	20.8	1.95	2.65
Dining Workplane	Illuminance	Fc	46.44	82.1	14.1	3.29	5.82
Mens_Workplane	Illuminance	Fc	41.94	73.8	17.4	2.41	4.24
Womens_Workplane	Illuminance	Fc	42.99	71.4	16.1	2.67	4.43

1. LUMINAIRE DATA IS TESTED TO INDUSTRY STANDARDS UNDER LABORATORY CONDITIONS. OPERATING VOLTAGE AND NORMAL MANUFACTURING TOLERANCES OF LAMP, BALLAST, AND LUMINAIRE MAY AFFECT FIELD RESULTS.

2. CONFORMANCE TO FACILITY CODE AND OTHER LOCAL REQUIREMENTS IS THE RESPONSIBILITY OF THE OWNER AND/OR THE OWNER'S REPRESENTATIVE.

3. THIS LAYOUT MAY NOT MEET TITLE 24 OR LOCAL ENERGY REQUIREMENTS. IF THIS LAYOUT NEEDS TO BE COMPLIANT WITH TITLE 24 OR OTHER ENERGY REQUIREMENTS, PLEASE CONSULT FACTORY WITH SPECIFIC DETAILS REGARDING PROJECT REQUIREMENTS SO THAT REVISIONS MAY BE MADE TO THE DRAWING

SECURITY LIGHTING™

2100 Gulf Road, Suite 400, Rolling Meadows, IL 60008

1-800-544-4844

UNLESS OTHERWISE SPECIFIED, ALL DIMENSIONS ARE IN INCHES

SCALE 1/4" = 1' 0"

DRAWN BY CLB

POINT-BY-POINT FOOTCANDLE PLOT FOR

MCDONALDS

2320 METROPOLITAN AVE

KANSAS CITY, KS 66106

NATIONAL STORE NUMBER

44936

DATE

12/12/25

DRAWING NUMBER

A252288A